# Exhibit B

This page intentionally left blank.

### **DRAFT RESOLUTION**

### Before the Zoning Administrator in and for the County of Monterey, State of California

### In the matter of the application of: BREIDENBACH (PLN230141) RESOLUTION NO. ----

Resolution by the Monterey County Zoning Administrator:

- Finding that the project qualifies as a Class 3 Categorical Exemption pursuant to section 15303 of the CEQA Guidelines and that none of the exceptions from section 15300.2 apply; and
- Approving a Design Approval to allow the construction of a detached two-story structure with a 754 square foot lower-level garage and Use Permit to allow a 786 square foot accessory dwelling unit on the upper level which exceed the 16 feet in height requirements.

[PLN230141, BREIDENBACH, 7650 Mills Road, Monterey, Greater Monterey Peninsula Area Plan (APN: 259-111-028-000)]

The BREIDENBACH application (PLN230141) came on for hearing before the Monterey County Zoning Administrator on March 28, 2024. Having considered all the written and documentary evidence, the administrative record, the staff report, oral testimony, and other evidence presented, the Monterey County Planning Commission finds and decides as follows:

### FINDINGS

CONSISTENCY - The Project, as conditioned, is consistent with the 1. FINDING: applicable plans and policies which designate this area as appropriate for development. **EVIDENCE:** During the course of review of this application, the project has been a) reviewed for consistency with the text, policies, and regulations in: The 2010 Monterey County General Plan; \_ Greater Monterey Peninsula Area Plan; and Monterey County Zoning Ordinance (Title 21). No conflicts were found to exist. No communications were received during the course of review of the project indicating any inconsistencies with the text, policies, and regulations in these documents. Allowed Use. The 2.43 acre parcel is located at 7650 Mills Road, b) Monterey, (Assessor's Parcel Number 259-111-028-000), within the Greater Monterey Peninsula Area Plan. The parcel is zoned Rural

Density Residential with a Building Site 6, Urban Reserve, Design Control and Site Plan Review zoning district overlays or "RDR/B-6-UR-D-S". The construction of a single-family dwelling and accessory structures are principally allowed uses within the RDR zoning district pursuant to Monterey County Zoning Ordinance (Title 21) Chapter 21.16 (Rural Density Residential). The proposed project includes construction of a 1,547 square foot detached two-story structure that exceeds 16 feet in height, inclusive of a 793 square foot accessory dwelling unit on upper the level and a 754 square foot garage on the lower level. Therefore, the project is an allowed land use for this site, subject to the granting of a Use Permit and Design Approval.

- c) The Urban Reserve or "UR" zoning district overlay requires discretionary permits be referred to the appropriate city for review and recommendation prior to action by an Appropriate Authority. The City of Monterey Planning Department was contacted on March 11, 2024, for comments and no comments on the project were received.
- d) <u>Lot Legality.</u> The subject property (2.43 acres), APN 259-111-028-000, is identified on the Record of Survey filed in Volume 26, page 11 of Monterra Ranch, recorded September 25, 2003, on the Survey Maps, Page 111. Therefore, the County recognizes the subject property as a legal lot of record.
- Design/Neighborhood and Community Character. The property is e) subject to the Design Control "D" zoning overlay district, which requires review of proposed development to assure protection of the public viewshed, neighborhood character, and to assure the visual integrity of certain developments without imposing undue restrictions on a private property, see Title 21 Chapter 21.44. The project includes a Design Approval and the requirements to grant the Design Approval are met in this case. HCD staff has reviewed the proposal and determined that the development has been appropriately sited and designed consistent with viewshed policy and the neighborhood character. The architecture design is consistent with the existing single family dwelling, and the proposed structure is not visible from any public viewing area. Enhancing the architecture style, the structure incorporates earth tone colors and materials that consist of aged white plaster siding at exterior walls, window frame and color to match existing main structure and slate roof. All structures incorporate natural looking materials that blend well with the surrounding environment. As shown on the exterior main house lighting plan, all proposed site lighting is downlit, shielded, and unobtrusive.
- f) <u>Development Standards.</u> The project is consistent with the development standards of RDR/B-6-UR-D-S. Pursuant to Title 21 section 21.16.060, development standards for the RDR zoning district, in a subdivision where a lot or lots have a designated building envelope, the two-story structure inclusive of a garage at lower level and an accessory dwelling unit at lower level as proposed shall be located wholly within the building envelope unless otherwise approved in the subdivision process. The proposed two-story structure is located within the designated building envelope with the overall height of 29 feet 8 inches. A height verification condition (Condition No. 4) has been applied. Per Title 21

section 21.64.030.E.5, a 16 height limit for Accessory Dwelling Units is established. A Use Permit is applied to this project as the detached garage which the ADU is situated above does not comply with height regulations for the zoning district in which it is proposed and exceeds 16 feet in height. As proposed, the project deviates from the height requirements however it better achieves the policies of the General Plan and regulations of this Title. The total building site coverage for the proposed project is 5.46%, which is below the limit of 25%. The project size, height, and setbacks are all within the allowed limits of the development standards of RDR zoning district. Therefore, as proposed, the project meets all required development standards of Title 21 sections 21.16.060 and 21.64.030.

- g) The application was reviewed by the Environmental Health Bureau to ensure adequate sewage disposal and water supply facilities exist and are readily available to serve the ADU. The Environmental Health Bureau made the determination that the property has adequate public facilities, and no further comments or conditions were provided (see Finding No. 3 and supporting evidence below).
- h) <u>Land Use Advisory Committee (LUAC) Review.</u> Based on the Board of Supervisors adopted LUAC Guidelines, this project warrants referral to the Greater Monterey Peninsula LUAC. However, the project was not referred as the LUAC does not currently meet due to a lack of quorum.
- i) The Project Planner conducted a site inspection on January 19, 2024 to verify that the project on the subject parcel conforms to the plans and regulations listed above.
- j) The application, project plans, staking & flagging photos, and related support materials submitted by the project applicant to Monterey County HCD-Planning found in Project File PLN230141.
- 2. FINDING: SITE SUITABILITY The site is physically suitable for the proposed development and/or use.
  - **EVIDENCE:** a) The project has been reviewed for site suitability by the following departments and agencies: HCD-Planning, HCD-Engineering Services, HCD-Environmental Services, Environmental Health Bureau, and Monterey County Regional Fire Protection District. County staff reviewed the application materials and plans to verify that the project on the subject site conforms to the applicable plans and regulations, and there has been no indication from these departments/agencies that the site is not suitable for the development. Conditions recommended have been incorporated.
    - b) Staff identified potential impacts to soils/slope stability. The following report was reported to address these issues:
      - "Geotechnical Investigation Design Phase report for Assessor's Parcel Number 259-111-028-000" (LIB230310) prepared by Greg Bloom, Monterey CA, August 9, 2023.

The report indicated that there are no physical or environmental constraints that would indicate that the site is not suitable for the use proposed. County staff has independently reviewed these reports and concurs with their conclusions.

- c) The Project Planner conducted a site inspection on January 19, 2024 to verify the site is suitable for the proposed use.
- d) The application, project plans, and related support materials submitted by the project applicant to Monterey County HCD-Planning found in Project File PLN230141.

# 3. FINDING: HEALTH AND SAFETY – The establishment, maintenance, or operation of the project applied for will not under the circumstances of this particular case be detrimental to the health, safety, peace, morals, comfort, and general welfare of persons residing or working in the neighborhood of such proposed use, or be detrimental or injurious to property and improvements in the neighborhood or to the general welfare of the County.

- **EVIDENCE:** a) The project was reviewed by HCD-Planning, HCD-Engineering Services, HCD-Environmental Services, Environmental Health Bureau (EHB), and the Monterey County Regional Fire Protection District. The respective agencies have recommended conditions, where appropriate, to ensure that the project will not have an adverse effect on the health, safety, and welfare of persons either residing or working in the neighborhood.
  - b) Necessary utilities will be provided. Water service will be provided by Canada Woods Water Company. As proposed, the project will be served by an onsite septic system. The Environmental Health Bureau reviewed the application and found it acceptable with no conditions.
  - c) The Project Planner conducted a site inspection on January 19, 2024 to verify that the project on the subject parcel is suitable for this use.
  - d) The application, project plans, and related support materials submitted by the project applicant to Monterey County HCD-Planning found in Project File PLN230141.
- 4. FINDING: NO VIOLATIONS The subject property is in compliance with all rules and regulations pertaining to zoning uses, subdivision, and any other applicable provisions of the County's zoning ordinance. No violations exist on the property.
  - **EVIDENCE:** a) Staff reviewed Monterey County HCD-Planning and HCD-Building Services records and is not aware of any violations existing on subject property.
    - b) The Project Planner conducted a site inspection on January 19, 2024 to and researched County records and did not identify any violations on the property.
    - c) The application, project plans, and related support materials submitted by the project applicant to Monterey County HCD-Planning found in Project File PLN230141.

15303 categorically exempts new construction of one single family

# **5.** FINDING: CEQA (Exempt) – The project is categorically exempt from environmental review and no unusual circumstances were identified to exist for the proposed project. EVIDENCE: a) California Environmental Quality Act (CEQA) Guidelines section

residence, second dwelling unit, and accessory structures within residential zoned areas.

- b) The proposed project involves the construction of a single family residence, attached accessory dwelling unit and attached garage within a residential zoned area.
- c) None of the exceptions under CEQA Guidelines Section 15300.2 apply to this project. The project does not involve a designated historical resource, a hazardous waste site, development located near or within view of a scenic highway, unusual circumstances that would result in a significant effect, or development that would result in a cumulative significant impact.
- d) No adverse environmental effects were identified during staff review of the development application during a site visit on January 19, 2024.
- e) See supporting Finding Nos. 1 and 2. The application, project plans, and related support materials submitted by the project applicant to Monterey County HCD-Planning found in Project File PLN230141.
- 6.FINDING:APPEALABILITY The decision on this project may be appealed to the<br/>Planning Commission.EVIDENCE:Pursuant to Title 21 section 21.80.040.B, the Planning Commission is<br/>the appropriate appeal authority to consider discretionary decision of the

### **DECISION**

**NOW, THEREFORE**, based on the above findings and evidence, the Zoning Administrator does hereby:

Zoning Administrator.

- 1) Find the project qualifies for a Class 3 Categorical Exemption pursuant to CEQA Guidelines section 15303; and
- 2) Approve a Design Approval to allow the construction of a detached 754 square foot lower-level garage and Use Permit to allow a 786 square foot accessory dwelling unit on the upper level, which exceeds the 16 feet in height requirements.

All of which are in general conformance with the attached sketch and subject to the attached conditions, all being attached hereto and incorporated herein by reference.

**PASSED AND ADOPTED** this 28<sup>th</sup> day of March, 2024.

Mike Novo, AICP Zoning Administrator

COPY OF THIS DECISION MAILED TO APPLICANT ON

THIS APPLICATION IS APPEALABLE TO THE PLANNING COMMISSION.

# IF ANYONE WISHES TO APPEAL THIS DECISION, AN APPEAL FORM MUST BE COMPLETED AND SUBMITTED TO THE SECRETARY OF THE PLANNING ALONG WITH THE APPROPRIATE FILING FEE ON OR BEFORE \_\_\_\_\_\_.

This decision, if this is the final administrative decision, is subject to judicial review pursuant to California Code of Civil Procedure Sections 1094.5 and 1094.6. Any Petition for Writ of Mandate must be filed with the Court no later than the 90th day following the date on which this decision becomes final.

### <u>NOTES</u>

You will need a building permit and must comply with the Monterey County Building Ordinance in every respect.

Additionally, the Zoning Ordinance provides that no building permit shall be issued, nor any use conducted, otherwise than in accordance with the conditions and terms of the permit granted or until ten days after the mailing of notice of the granting of the permit by the appropriate authority, or after granting of the permit by the Planning Commission in the event of appeal.

Do not start any construction or occupy any building until you have obtained the necessary permits and use clearances from Monterey County HCD-Planning and HCD-Building Services Department office in Salinas.

This permit expires 3 years after the above date of granting thereof unless construction or use is started within this period.

Form Rev. 1-27-2021

# **County of Monterey HCD Planning**

### DRAFT Conditions of Approval/Implementation Plan/Mitigation Monitoring and Reporting Plan

PLN230141

### 1. PD001 - SPECIFIC USES ONLY

Responsible Department: Planning

Condition/Mitigation This Use permit (PLN230141) allows the construction of a 754 square foot lower-level **Monitoring Measure:** garage and a 793 square foot accessory dwelling unit on the upper-level which exceed 16 feet in height. The property is located at 7650 Mills Road, Monterey (Assessor's Parcel Number 259-111-028-000), Greater Monterey Peninsul Area Plan. This permit was approved in accordance with County ordinances and land use regulations subject to the terms and conditions described in the project file. Neither the uses nor the construction allowed by this permit shall commence unless and until all of the conditions of this permit are met to the satisfaction of the Director of HCD - Planning. Any use or construction not in substantial conformance with the terms and conditions of this permit is a violation of County regulations and may result in modification or revocation of this permit and subsequent legal action. No use or construction other than that specified by this permit is allowed unless additional permits are approved by the appropriate authorities. To the extent that the County has delegated any condition compliance or mitigation monitoring to the Monterey County Water Resources Agency, the Water Resources Agency shall provide all information requested by the County and the County shall bear ultimate responsibility to ensure that conditions and mitigation measures are properly fulfilled. (HCD - Planning)

Compliance or Monitoring Action to be The Owner/Applicant shall adhere to conditions and uses specified in the permit on an ongoing basis unless otherwise stated.

### 2. PD002 - NOTICE PERMIT APPROVAL

Responsible Department: Planning

Performed:

Condition/Mitigation The applicant shall record a Permit Approval Notice. This notice shall state:

"A Use Permit (Resolution Number \_\_\_\_\_) was approved by Zoning Administrator for Assessor's Parcel Number 259-111-028-000 on March 28, 2024. The permit was granted subject to 7 conditions of approval which run with the land. A copy of the permit is on file with Monterey County HCD - Planning."

Proof of recordation of this notice shall be furnished to the Director of HCD - Planning prior to issuance of grading and building permits, Certificates of Compliance, or commencement of use, whichever occurs first and as applicable. (HCD - Planning)

**Compliance or Monitoring Action to be Performed:** Prior to the issuance of grading and building permits, certificates of compliance, or commencement of use, whichever occurs first and as applicable, the Owner/Applicant shall provide proof of recordation of this notice to the HCD - Planning.

### 3. PD003(A) - CULTURAL RESOURCES NEGATIVE ARCHAEOLOGICAL REPORT

Responsible Department: Planning

Condition/Mitigation lf, during the course of construction, cultural, archaeological, historical or **Monitoring Measure:** paleontological resources are uncovered at the site (surface or subsurface resources) work shall be halted immediately within 50 meters (165 feet) of the find until a qualified professional archaeologist can evaluate it. Monterey County HCD - Planning and a archaeologist (i.e., archaeologist registered the Register qualified an with of immediately Professional Archaeologists) shall be contacted by the responsible individual present on-site. When contacted, the project planner and the archaeologist shall immediately visit the site to determine the extent of the resources and to develop proper mitigation measures required for recovery. (HCD - Planning)

**Compliance or** The Owner/Applicant shall adhere to this condition on an on-going basis.

Action to be

Performed: Prior to the issuance of grading or building permits and/or prior to the recordation of the final/parcel map, whichever occurs first, the Owner/Applicant shall include requirements of this condition as a note on all grading and building plans. The note shall state "Stop work within 50 meters (165 feet) of uncovered resource and contact Monterey County HCD - Planning and a qualified archaeologist immediately if cultural, archaeological, historical or paleontological resources are uncovered."

When contacted, the project planner and the archaeologist shall immediately visit the site to determine the extent of the resources and to develop proper mitigation measures required for the discovery.

### 4. PD041 - HEIGHT VERIFICATION

### Responsible Department: Planning

Condition/Mitigation Monitoring Measure: The applicant shall have a benchmark placed upon the property and identify the benchmark on the building plans. The benchmark shall remain visible on-site until final building inspection. The applicant shall provide evidence from a licensed civil engineer or surveyor to the Director of HCD - Building Services for review and approval, that the height of the structure(s) from the benchmark is consistent with what was approved on the building permit associated with this project. (HCD - Planning and HCD - Building Services)

**Compliance or Monitoring Action to be Performed:**Prior to the issuance of grading or building permits, the Owner/Applicant shall have a benchmark placed upon the property and identify the benchmark on the building plans. The benchmark shall remain visible onsite until final building inspection.

Prior to the foundation pre-pour inspection, the Owner/Applicant shall provide evidence from a licensed civil engineer or surveyor, to the Director of HCD - Building Services for review and approval, that the height of first finished floor from the benchmark is consistent with what was approved on the building permit.

Prior to the final inspection, the Owner/Applicant/Engineer shall provide evidence from a licensed civil engineer or surveyor, to the Director of HCD - Building Services for review and approval, that the height of the structure(s) from the benchmark is consistent with what was approved on the building permit.

### 5. EHSP01 – Onsite Wastewater Treatment System Permit (Non-Standard)

Responsible Department: Health Department

Condition/Mitigation Monitoring Measure: The Environmental Health Bureau has determined that the existing septic tank on the subject property does not meet the minimum standards specified by Table 6 of Monterey County Code 15.20, specifically, Per Table 6 of Monterey County Code 15.20, the 4 bedroom dwelling + 1 bedroom ADU would result in 600 gallons of wastewater generation per day – requiring a minimum of 2,000 gallons of septic tank capacity.

Compliance or<br/>Monitoring<br/>Action to be<br/>Performed:Priortoissuanceofconstructionpermit(s),theapplicantshallsubmittotheEnvironmentalHealthBureauforreviewandapprovalanOnsiteWastewaterTreatmentSystem(OWTS)permit application, supportingdocumentationandall applicable fees.

### 6. PW0043 - REGIONAL DEVELOPMENT IMPACT FEE

Responsible Department: Public Works

- Condition/Mitigation<br/>Monitoring Measure:Prior to issuance of building permits, applicant shall pay the Regional Development<br/>Impact Fee (RDIF) pursuant to Monterey Code Chapter 12.90. The fee amount shall<br/>be determined based on the parameters adopted in the current fee schedule.
  - Compliance or<br/>Monitoring<br/>Action to bePriortoissuanceofBuildingPermitsOwner/ApplicantshallpayMonitoreyCountyBuildingServicesDepartmentthetrafficmitigationfee.Owner/ApplicantshallsubmitPerformed:proof of payment to the HCD-EngineeringServices.Services.Services.Services.

### 7. PW0045 – COUNTYWIDE TRAFFIC FEE

Responsible Department: Public Works

- Condition/Mitigation Monitoring Measure: Prior to issuance of building permits, the Owner/Applicant shall pay the Countywide Traffic Fee or the ad hoc fee pursuant to General Plan Policy C-1.8. The fee amount shall be determined based on the parameters in the current fee schedule.
  - Compliance or<br/>Monitoring<br/>Action to be<br/>Performed:Prior to issuance of Building Permits, the Owner/Applicant shall pay Monterey County<br/>HCD-Building Services the traffic mitigation fee. The Owner/Applicant shall submit<br/>proof of payment to HCD-Engineering Services.

This page intentionally left blank

# LOT ZONII A.P.N LEGA HEIGH SETB STOR BU

T T SIT

BUI PER\

V



# PROJECT DATA

SIZE NING .N. GAL DESCRIPTION GHT (MAX. ALLOWED) BACKS (MIN. ALLOWED) ORIES: 2	RDR-B6-U 259-111-C BLOCK 10 25FT	28-000 4 - LOT 10		S.OFT	
OOR AREA					
BUILDING SITE COVERAGE A	LOWED	29,620.0 SQ.FT. TOTAL ALLOWED			25%
MAIN DWELLING LOWER LEVEL (INCLUDED UPPER LEVEL ADU	GARAGE)	EXISTING 4,955.0 SQ.FT.		PROPOSED 4,955.0 SQ.FT. 754.0 SQ.FT. 768.0 SQ.FT.	
TOTAL GROSS FLOOR ARE	4,955.0 SQ.FT.	8.7%	6,477.0 SQ.FT.	6.7%	
TE COVERAGE					
JILDING FOOTPRINT		29,620.0 SQ.FT.	TOTAL	ALLOWED	25%
MAIN DWELLING ADU/GARAGE		8,312.0 SQ.FT.		8,312.0 SQ.FT. 954.0 SQ.FT.	
TOTAL		8,312.0 SQ.FT.		9,266.0 SQ.FT.	
RVIOUS COVERAGE		EXISTING		PROPOSED	
WEST DRIVEWAY ADU DRIVEWAY		1,952.2 SQ.FT		1,952.2 SQ.FT 409.0 SQ.FT	
OTAL PERVIOUS COVERAG	;E	1.952.2 SQ.FT		2,361.2 SQ.FT.	1.9%

### TOTAL PERVIOUS COVERAGE | 1,952.2 SQ.FT | 2,361.2 SQ.FI. | 1.9% IMPERVIOUS COVERAGE 66.0 SQ.FT. 64.0 SQ.FT. WALKWAY ENTRY STAIRS DECK 99.0 SQ.FT. TOTAL IMPERVIOUS COVERAGE 229.0 SQ.FT. 1.9% 1,952.2 SQ.FT 8.0% 638.0 SQ.FT. 5.3% TOTAL GROSS COVERAGE

# SHEET INDEX

ARCHITECTURAL


- A1.0 COVER SHEET & GENERAL NOTES
- A1.1 TOPOGRAPHIC SURVEY
- A1.2 EXISTING SITE PLAN
- A1.3 PARTIAL SITE PLAN (PROPOSED)
- A1.4 SITE SECTIONS

- A1.4 SITE SECTIONS A1.5 AERIAL VIEW DIAGRAM A1.6 TRAFFIC CONTROL PLAN & TRUCK ROUTE A2.0 LOWER & UPPER LEVEL FLOOR PLANS (PROPOSED) A3.0 ELEVATION (PROPOSED) A4.0 ROOF PLANS (PROPOSED) A4.1 REFLECTED CEILING PLAN (PROPOSED) A5.0 WINDOW & DOOR SCHEDULE A6.0 MATERIALS

<u>LANDSCAPE</u>


L1 LANDSCAPE (PROPOSED)


- <u>CIVIL</u>
- C1 COVER SHEET & GENERAL NOTES
- C2 EXISTING SITE PLAN
- C3 GRADING & DRAINING C4 UTILITY PLAN
- C5 SECTIONS & DETAILS C6 EROSION AND SEDIMENT CONTROL PLAN C7 EROSION AND SEDIMENT CONTROL PLAN DETAILS

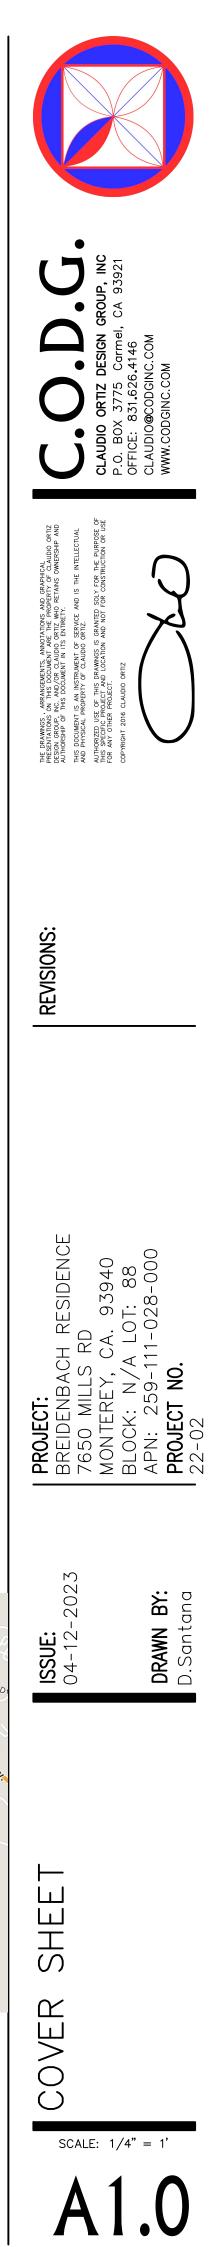

# SCOPE OF WORK

- 1. CONSTRUCTION OF A NEW DETACHED TWO-STORY STRUCTURE WITH A TWO-CAR GARAGE IN THE LOWER LEVEL AND AN ADU ON THE UPPER LEVEL.
- 2. NEW STRUCTURE TO MATCH MATERIALS TO THE EXISTING SFD.
- 3. EXTEND THE EXISTING DRIVEWAY TO CONNECT TO THE NEW DETACHED STRUCTURE.
- 4. NO TREE REMOVAL OR GRADING.
- 5. NO MODIFICATION TO THE EXISTING SINGLE-FAMILY DWELLING.

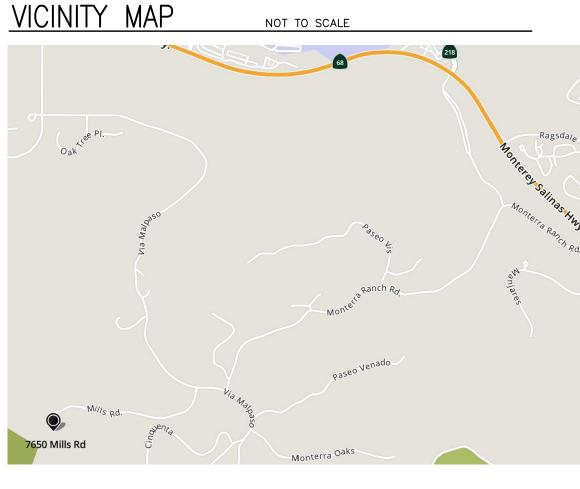

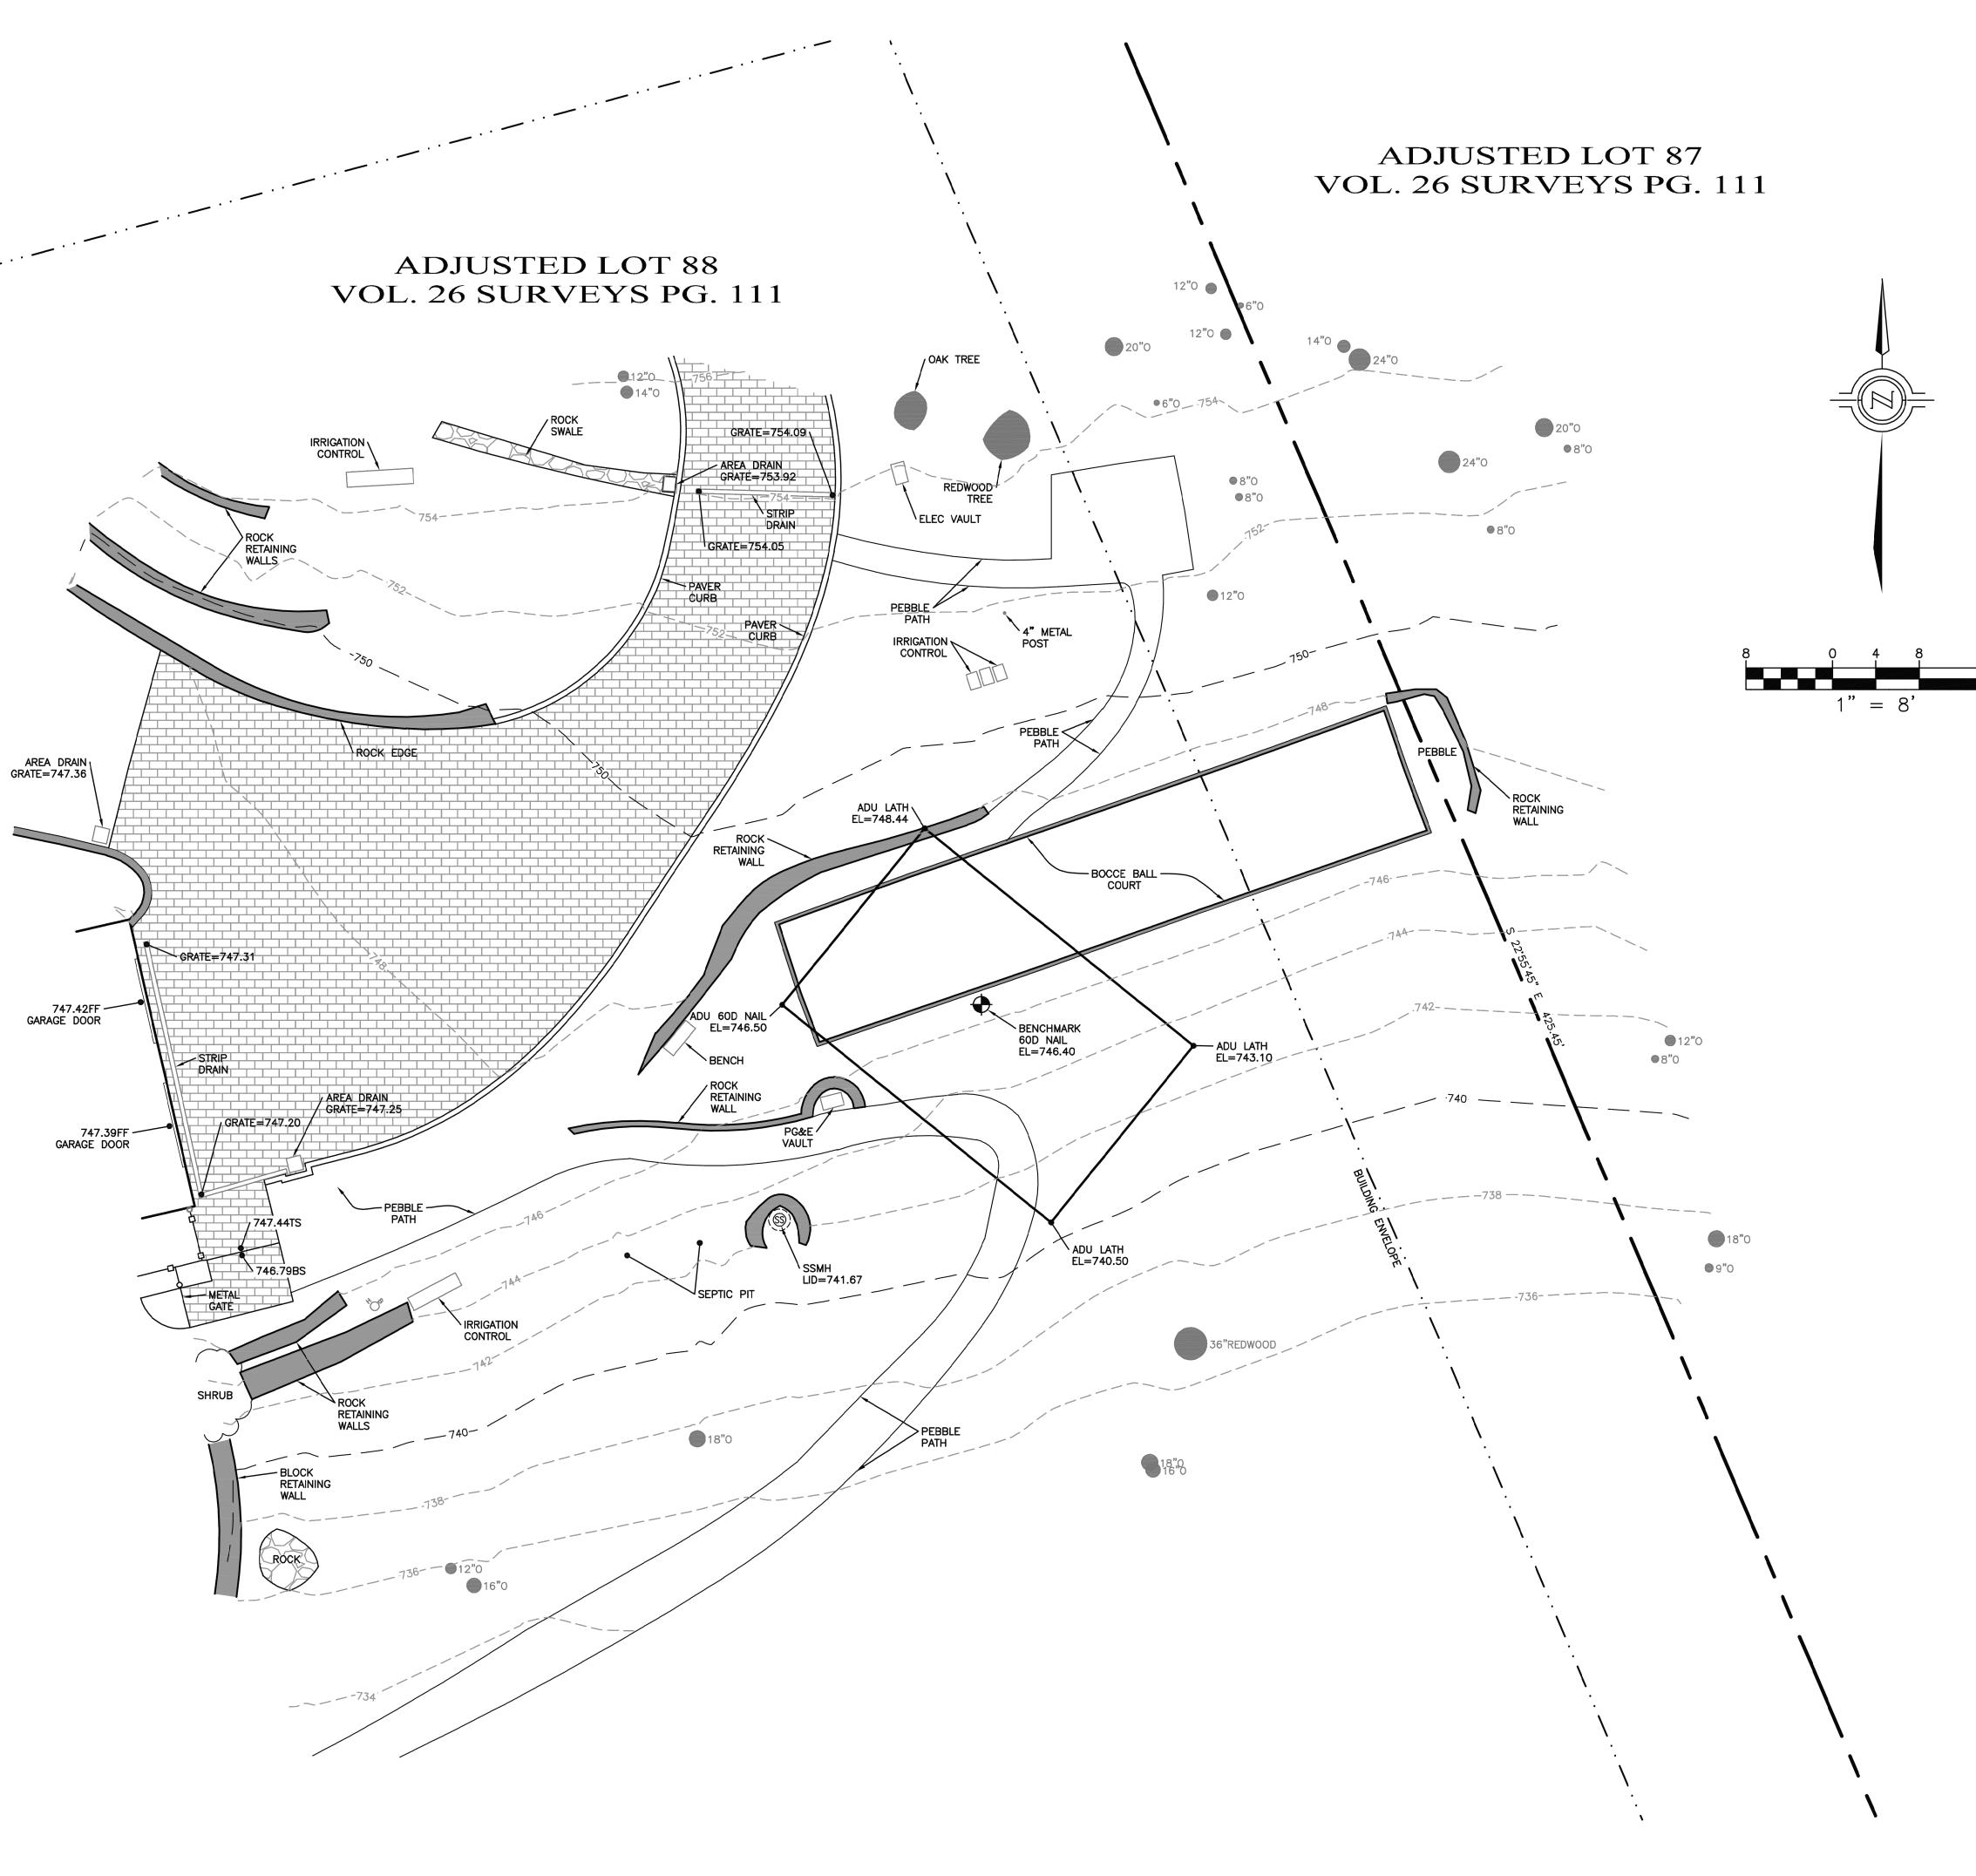

# LEGEND

0		-0	PROPERTY LINE BUILDING ENVELOPE WOOD FENCE WIRE FENCE METAL FENCE MAJOR CONTOUR MINOR CONTOUR
80.00 - 5	POT ELEVATION		
AC	ASPHALT	WM	WATER METER
BS CONC	BOTTOM STAIRS CONCRETE	$\bowtie$	WATER VALVE
DS E	EXISTING EXISTING GRADE ELEVATION		FIRE HYDRANT
EG EL		40°	HOSE BIB
ELEC FC	ELECTRICAL FACE OF CURB	00	BACKFLOW PREVENTOR
FL FP	FLOW LINE FINISH PAVEMENT	EL	ELECTRICAL METER
FW O	FACE OF WALL OAK TREE	GV	GAS VALVE
RL T	RIDGE LINE TREE	(GM)	GAS METER
TS TYP	TOP OF STAIRS TYPICAL	$\langle \textcircled{3} \rangle$	SEWER MANHOLE
		~ <del>36</del> 0	SEWER CLEANOUT
		0	DOWNSPOUT
		AC	PAVEMENT
		COI	NCRETE
		STO	ONE PAVERS

# NOTES

1. BOUNDARY DATA SHOWN HEREON WERE DETERMINED WITH THE BENEFIT OF A FIELD SURVEY SUPPLEMENTED BY RECORD DOCUMENTS. ALL BOUNDARY DATA SHOWN HEREON ARE FROM THE RECORDS PER GRANT DEED DOCUMENT #2013076328, AND SHOWN APPROXIMATE ONLY. THIS IS NOT A BOUNDARY SURVEY.

2. THIS TOPOGRAPHIC SURVEY IS PREPARED FOR DESIGN PURPOSES ONLY.

3. ENTITLEMENTS OR ENCUMBRANCES AFFECTING THIS PROPERTY MAY NOT NECESSARILY BE SHOWN.

4. DISTANCES SHOWN ARE EXPRESSED IN FEET AND DECIMALS THEREOF.

5. CONTOUR INTERVAL = ONE FOOT.

6. TREE TYPES ARE INDICATED WHERE KNOWN. DIAMETERS OF TREES ARE SHOWN IN INCHES AND ARE APPROXIMATE ONLY, TO BE VERIFIED BY AN APPROVED ARBORIST. TREES SMALLER THAN 6" ARE NOT NECESSARILY SHOWN. DIRECTION OF GROWTH AND DRIP LINE SHAPE TO BE VERIFIED BY OTHERS.

7. POSITION AND DIMENSIONS (IF ANY) OF BUILDINGS AND OTHER STRUCTURES ARE SHOWN HEREON APPROXIMATE ONLY DUE TO MEASUREMENT LIMITATIONS, IRREGULAR SHAPE OF BRICK FACING, POP-OUTS, BULL NOSE CORNERS, ETC.


8. NOT ALL UTILITY BOXES AND/OR UTILITY STRUCTURES ARE SHOWN INCLUDING BUT NOT LIMITED TO HOSE BIBS AND IRRIGATION VALVES. ONLY THE VISIBLE UTILITY BOXES AND/OR UTILITY STRUCTURES THAT WERE CONSIDERED TO CONVEY THE GENERAL UTILITY CONDITIONS ARE SHOWN.

9. A LOCAL BENCHMARK FOR THIS PROJECT IS A 60D NAIL SET NEAR BOCCE BALL COURT AS SHWON HEREON, HAVING AN ELEVATION OF 746.40 BASED UPON AN ASSUMED DATUM.


10. THIS MAP CORRECTLY REPRESENTS A SURVEY PREPARED BY ME AND/OR UNDER MY DIRECTION, FROM FIELD DATA COLLECTED IN NOVEMBER 2022.







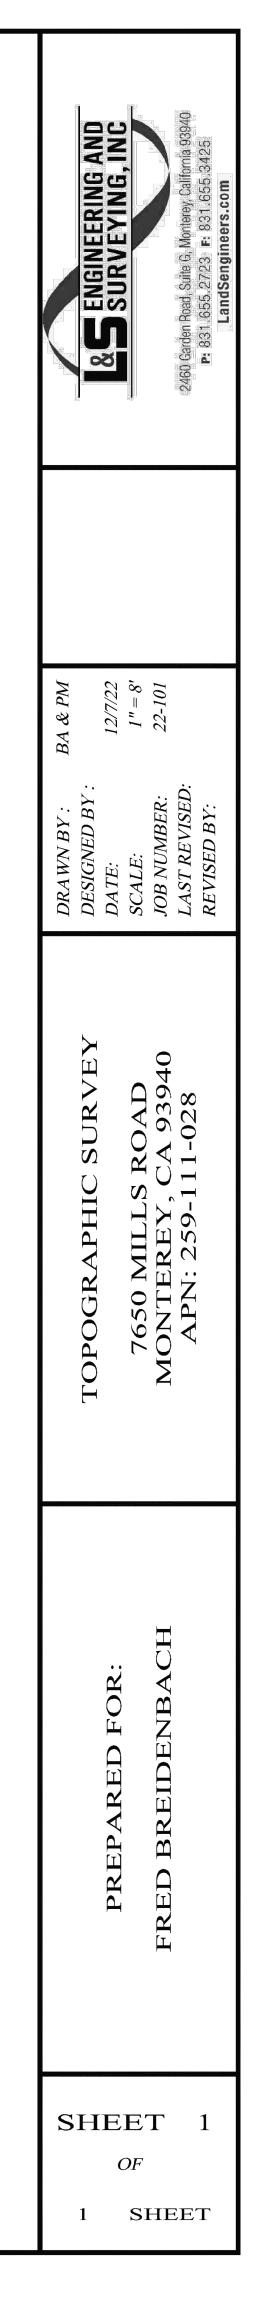




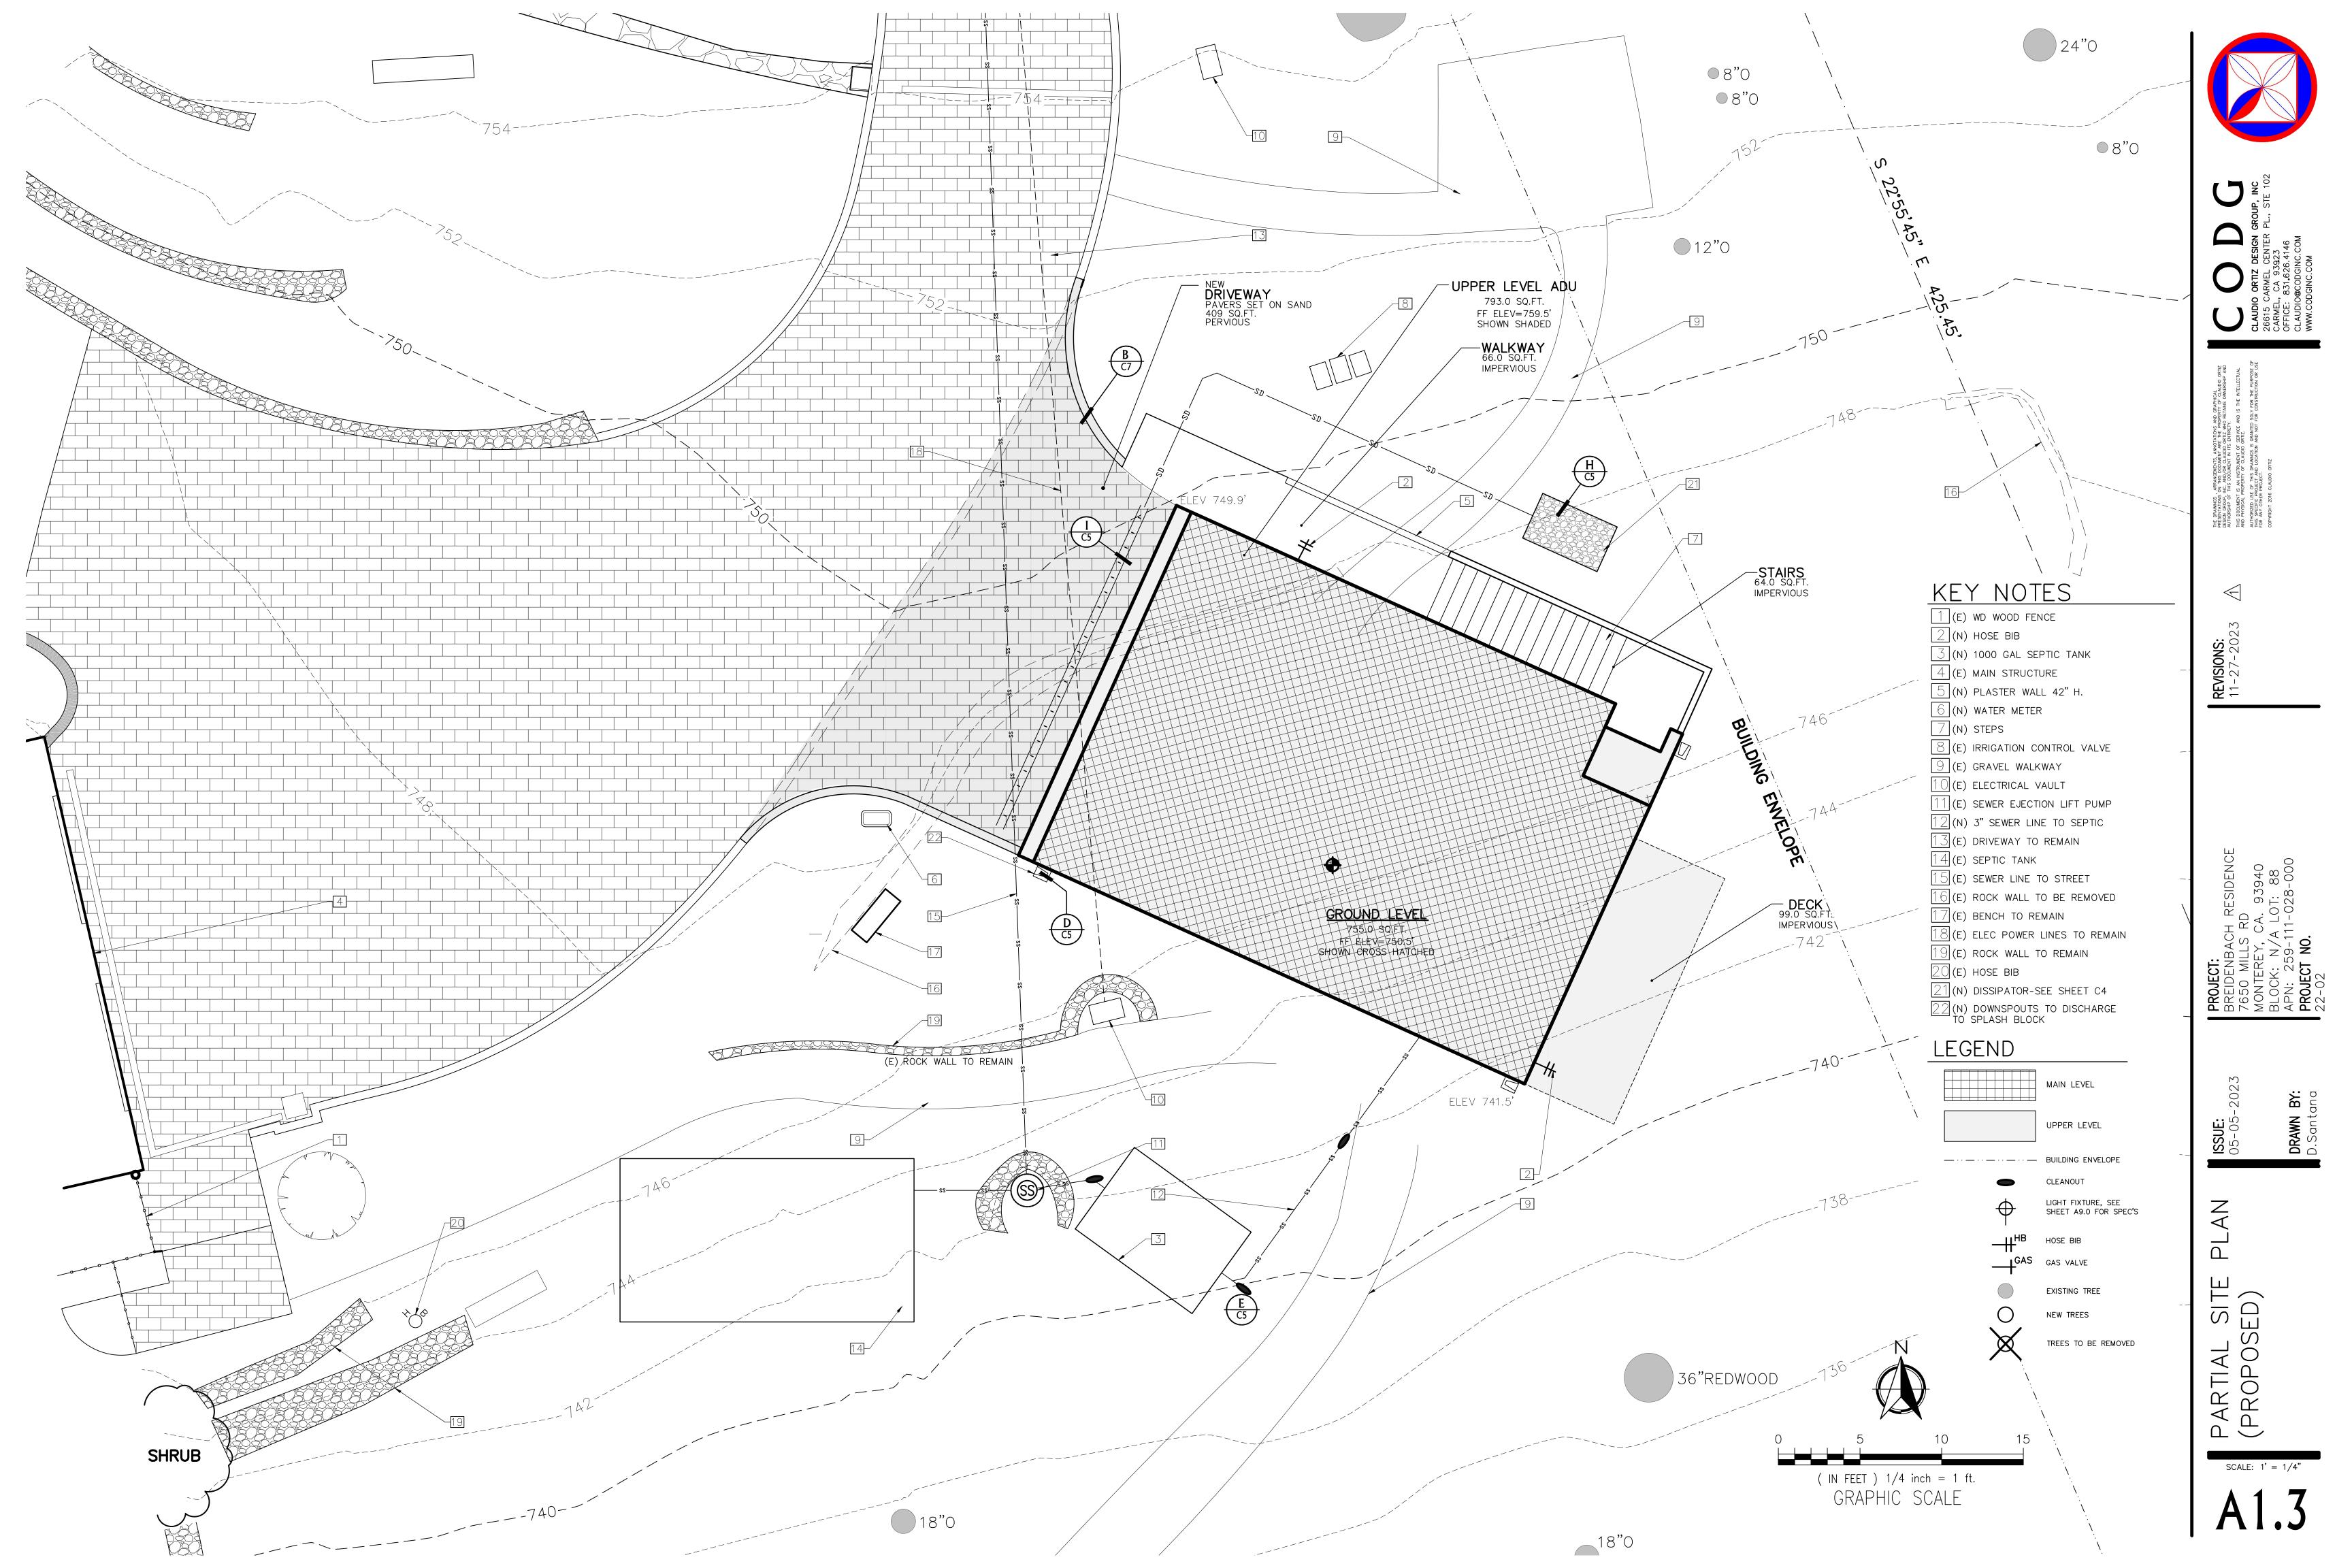

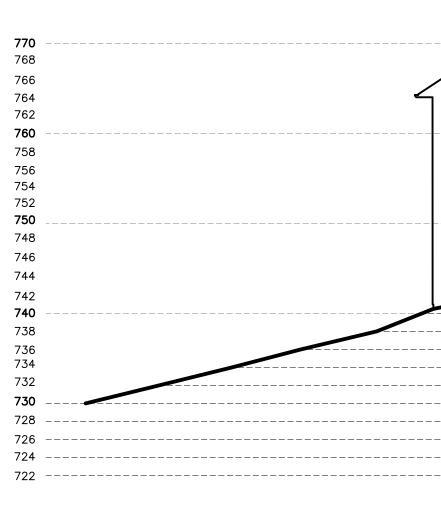

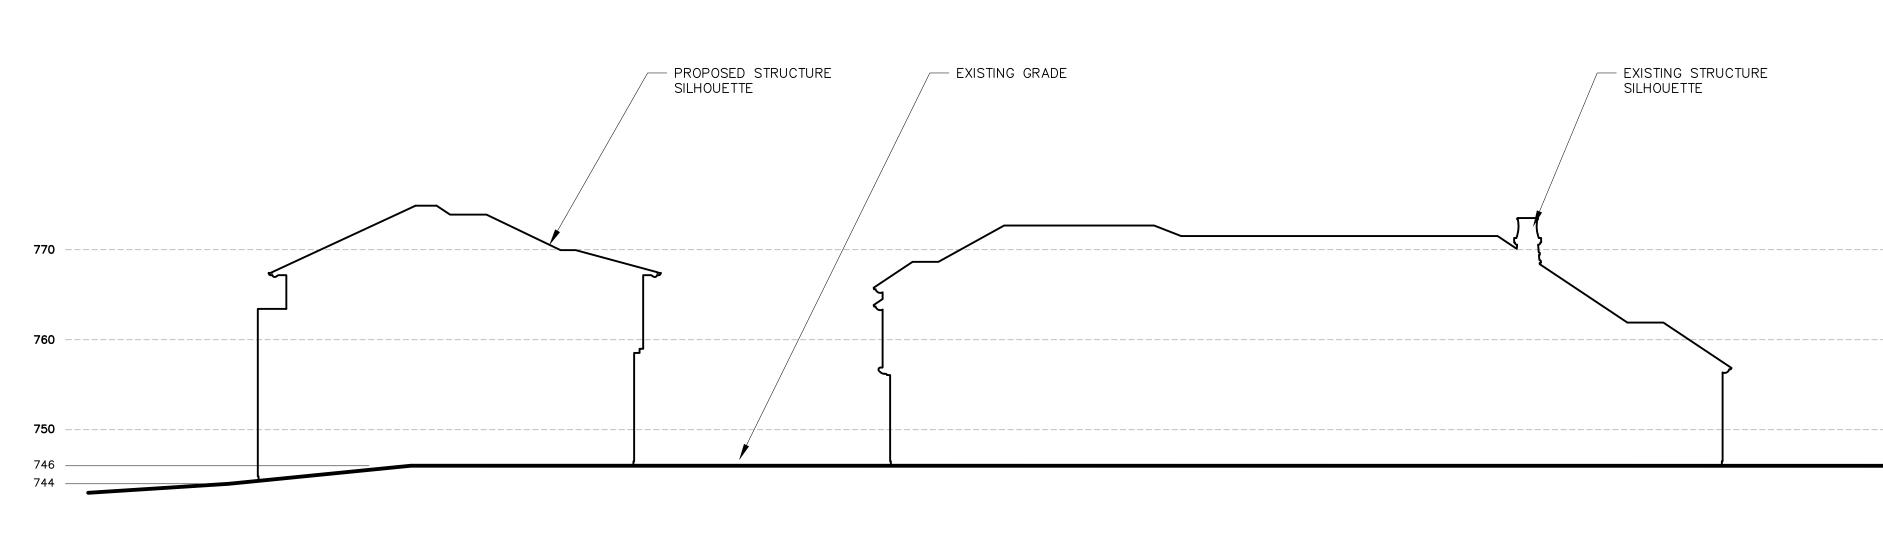

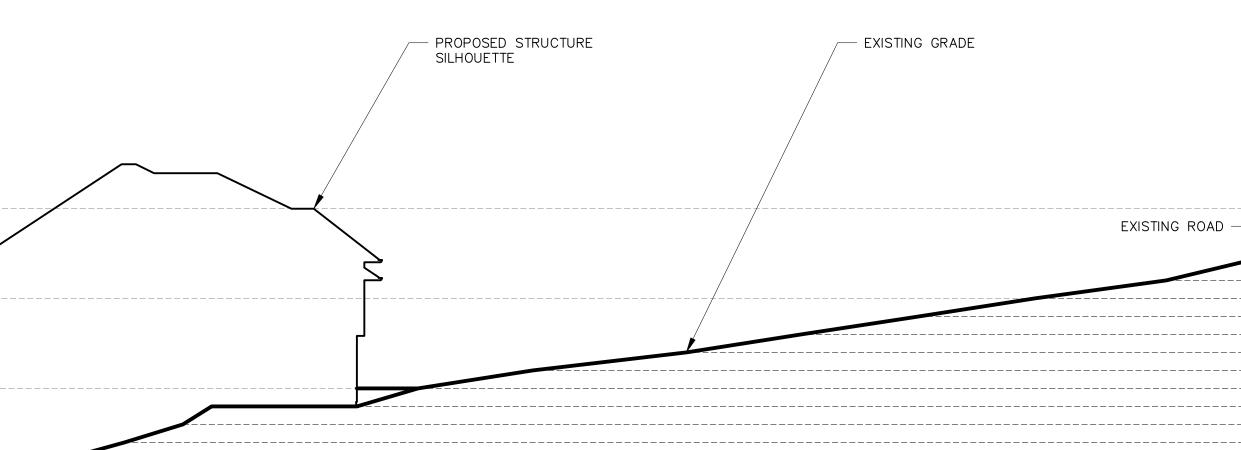

# <u>SECTION A</u>

<u>SECTION B</u>


	SITE SECTIONS	<b>ISSUE:</b> 04-04-2017	PROJECT: Breidenbach residence 7650 Mills RD Montfrey Ca 93940	REVIONS:	THE DRAWINGS , ARRANGEMENTS, ANNOTATIONS AND GRAPHICAL PRESENTATIONS ON THIS DOCUMENT ARE THE FROEPERTY OF CLAUDIO GRTZ DESION, GROUP, INC. AND/OF CLAUDIO ORTZ WHO RETAINS OWNERSHIP AND AUTHORSHIP OF THIS DOCUMENT IN ITS ENTRETY. THIS DOCUMENT IS AN INSTRUMENT OF SERVICE AND IS THE INTELLECTUAL AND PHYSICAL PROPERTY OF CLAUDIO ORTZ. AUTHORIZEL DUES OF THIS DRAWINGS IS GRANTED SOLY FOR THE PURPOSE OF THIS SECRETC PROLECTIVEN AND NOT FOR CONSTRUCTION OR USE	C D D D C CLAUDIO ORTIZ DESIGN GROUP, INC	
NTS		DRAWN BY:	BLOCK: N/A LOT: 88 APN: 259-111-028-000 <b>PROJECT NO.</b> 22-02		COPPRIENT ZOIG CLAUDIO ORTIZ	26615 CARMEL CENTER PLACE, STE 102 Carmel, CA 93923 OFFICE: 831.626.4146 CLAUDIO@CODGINC.COM WWW.CODGINC.COM	

 770
768
765
 764
 762
 760
 758
 756
 754
 752
 750
 748
 746
 744
 742
 740
 738
 736
 734
 732
 730
 728
 726
 724
 722


-----


\_\_\_\_\_


 	 770
 	 760
 	 750
	746 744
	742

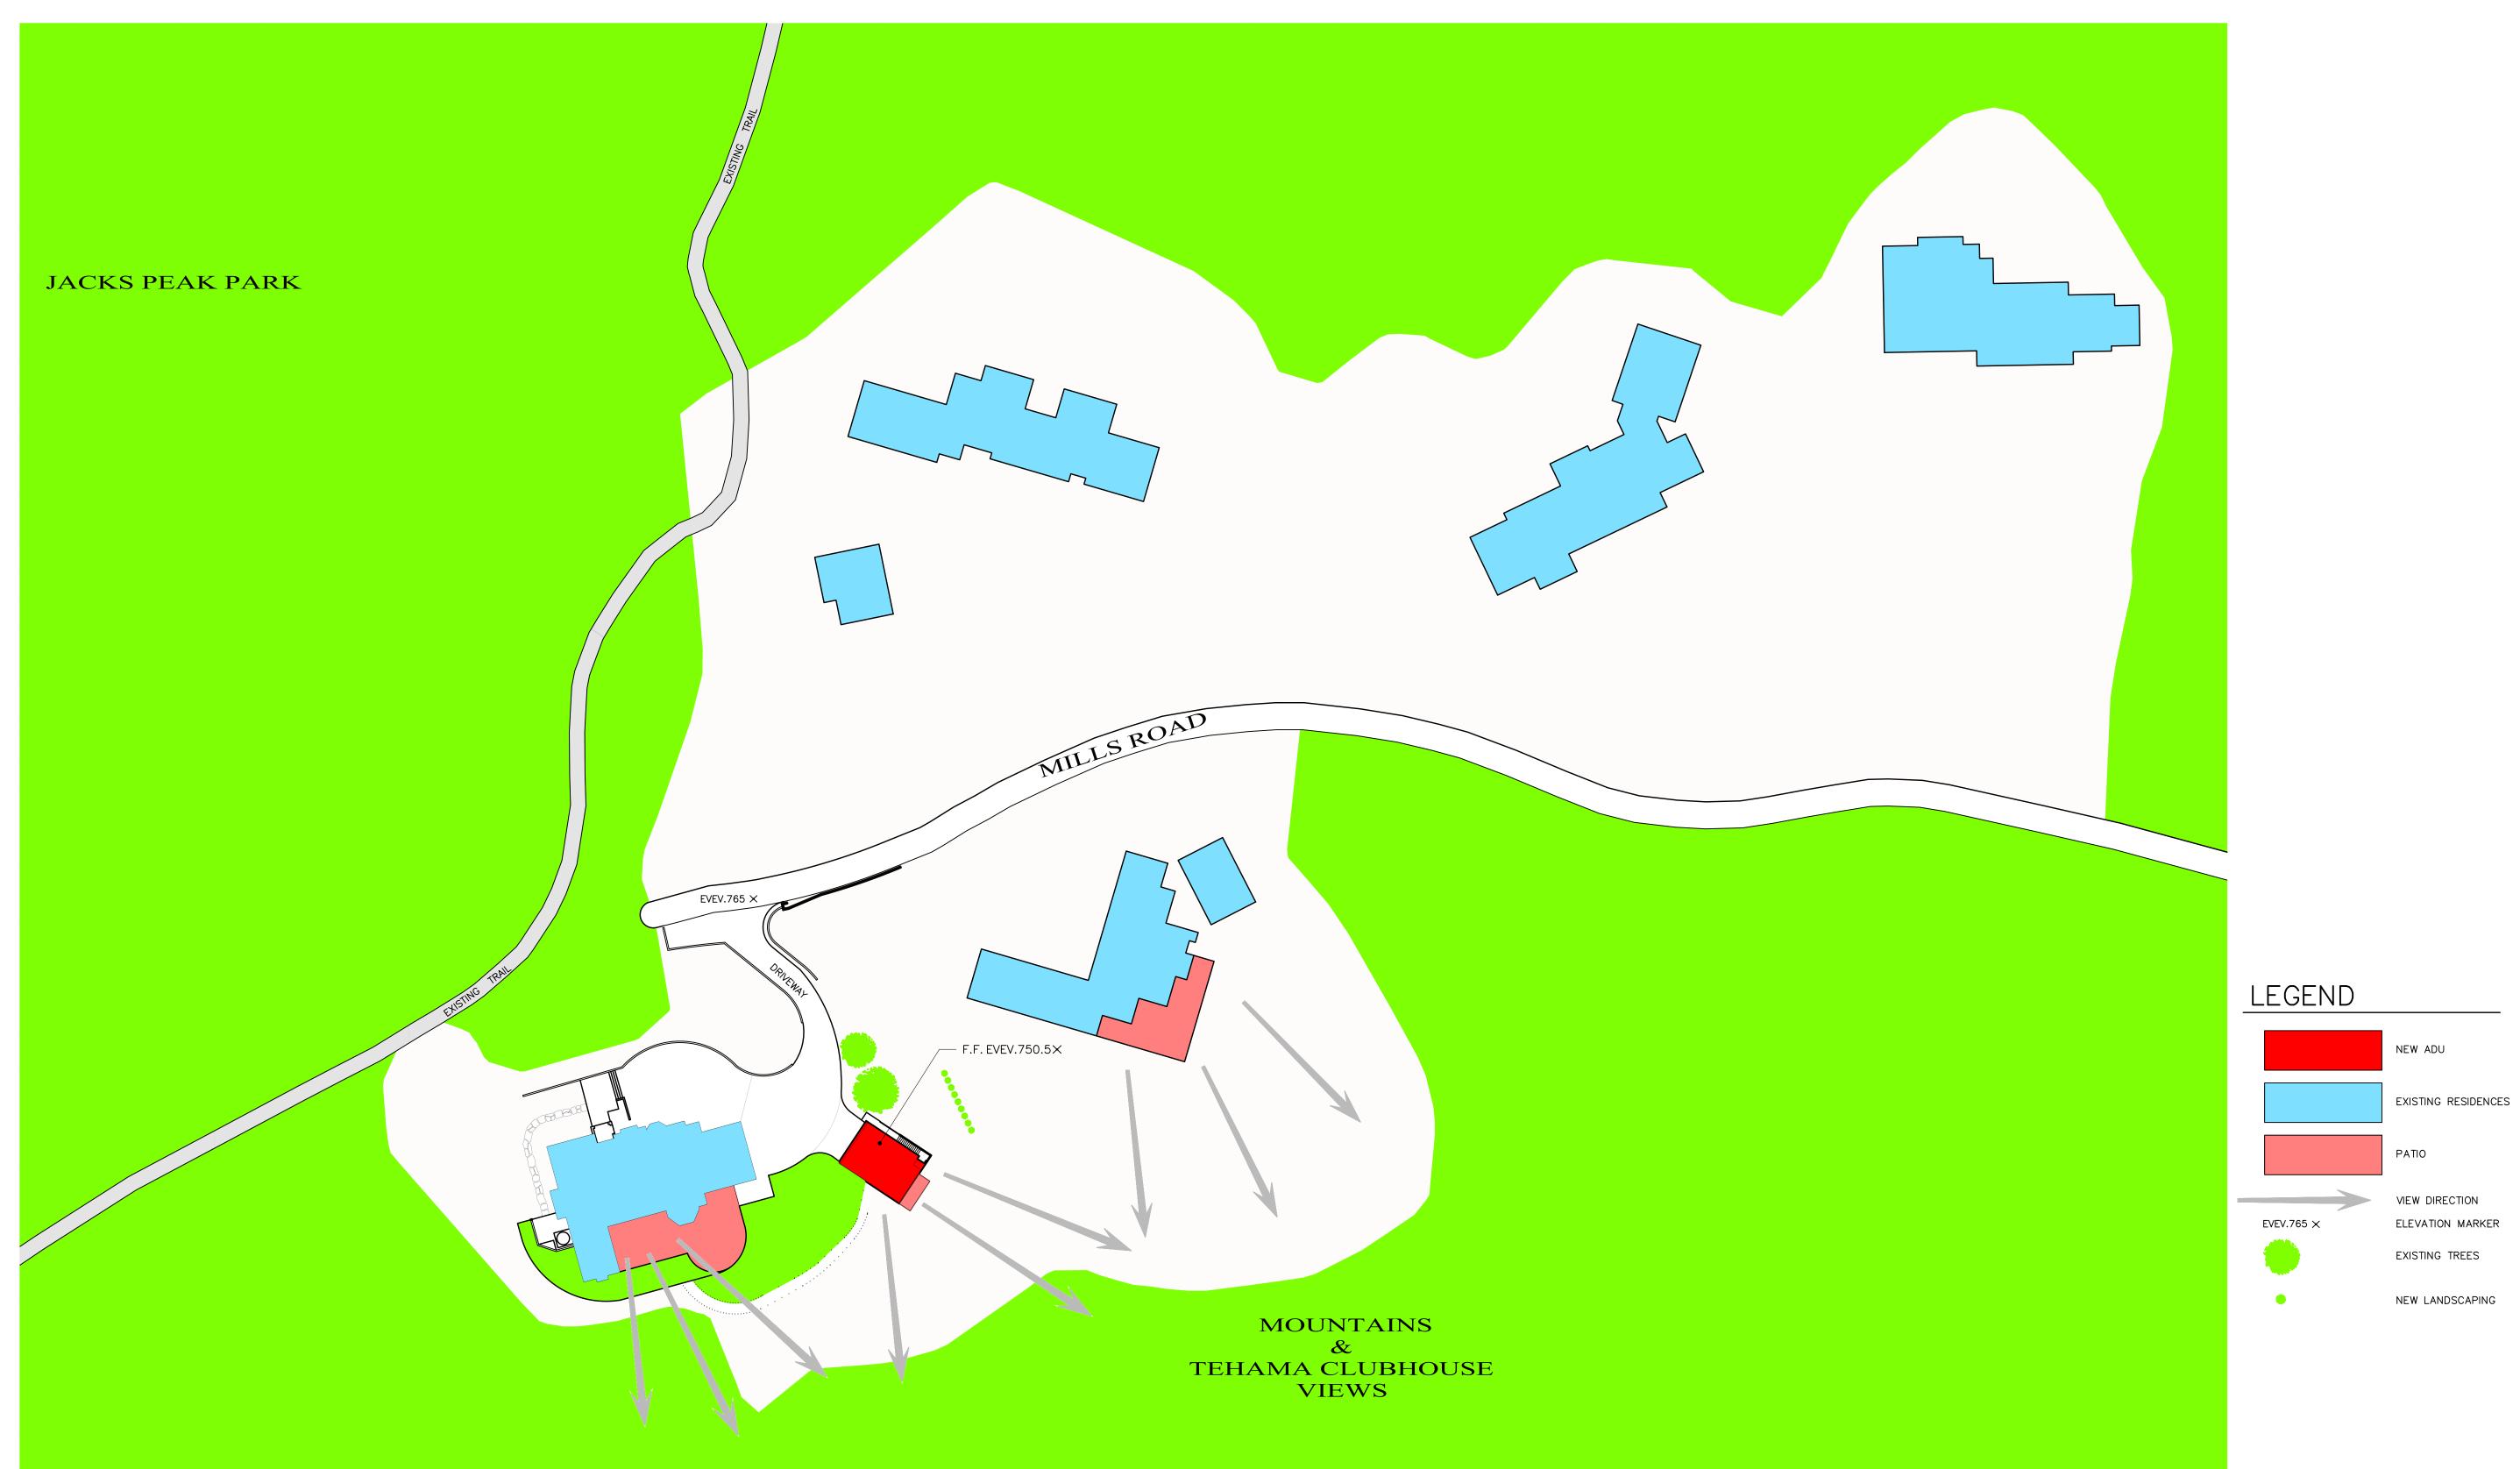



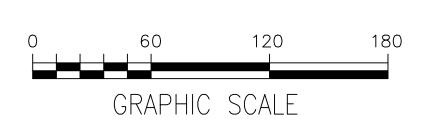

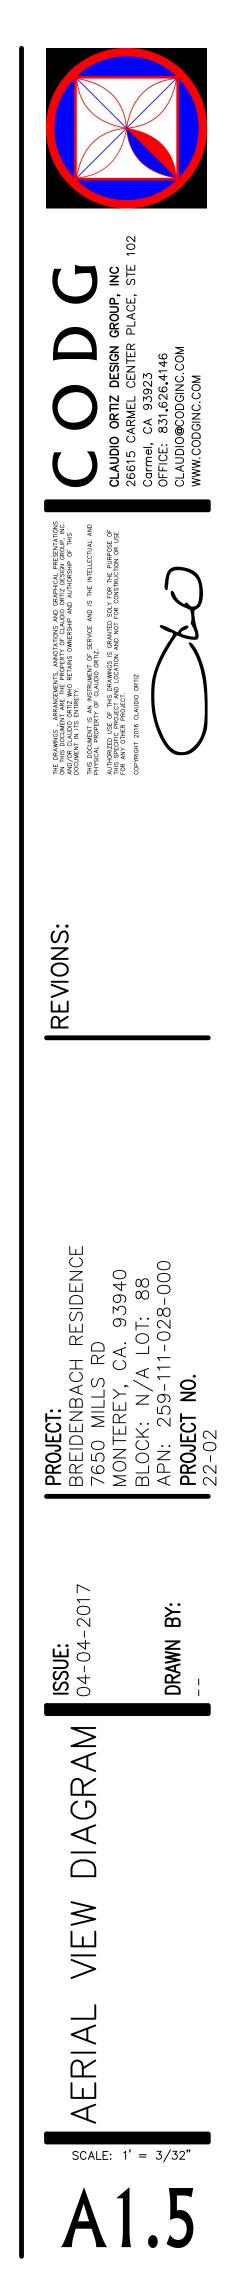

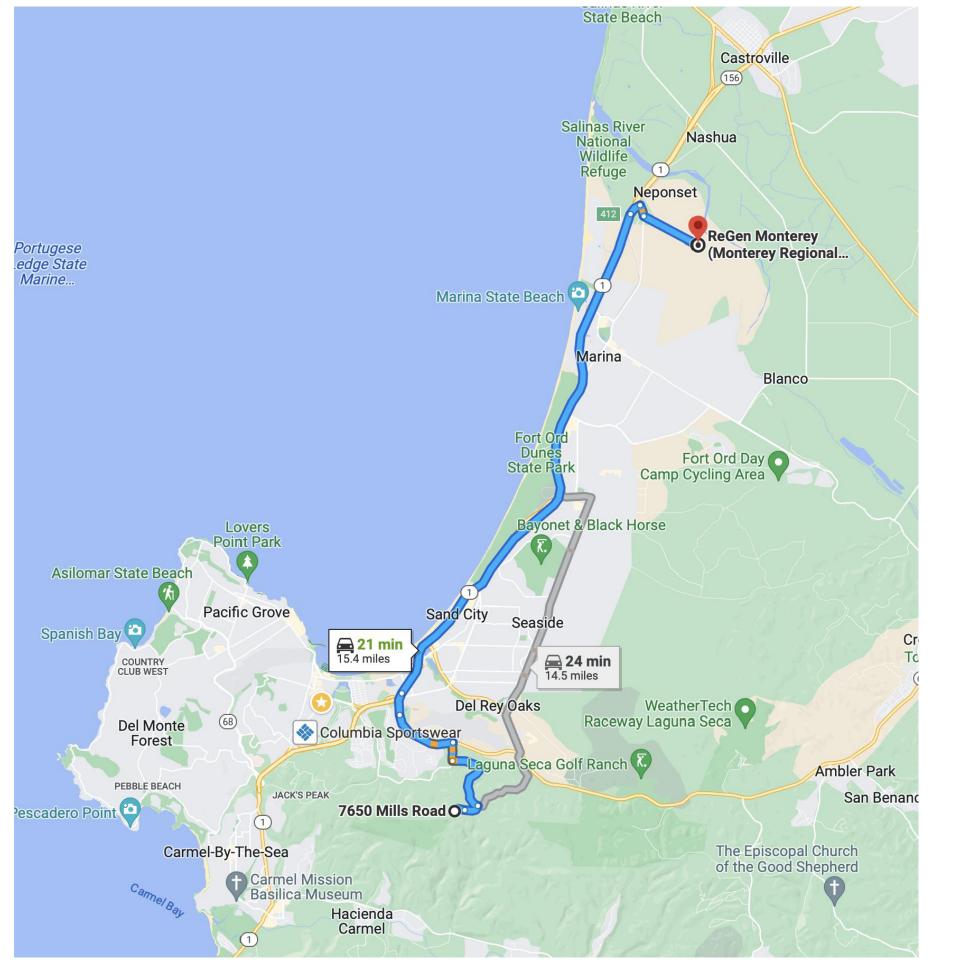

# TRAFFIC CONTROL PLAN NOTES


CONSTRUCTION MATERIALS EXPORT ROUTE OF TRAVEL

7650 MILLS RD MONTEREY, CA. 93940 259-111-028-000 PROJECT ROUTE FOR HAULING AWAY DEBRIS OR CONSTRUCTION MATERIALS.


- 1. TRUCKS WILL BE COMING IN FROM MILLS RAOD & VIA MALPASO TO HIGHWAY 68 2. THEN TO HIGHWAY 1 TO GO TO MARINA LAND FILL.
- 3. NOISE-GENERATING CONSTRUCTION ACTIVITIES ARE LIMITED TO THE HOURS BETWEEN 8 A.M. AND 5 P.M. MONDAY THROUGH SATURDAY; NO CONSTRUCTION NOISE IS ALLOWED ON SUNDAYS OR NATIONAL HOLIDAYS.


# ROAD SIGNAGE NOTES

- 1. CONSTRUCTION AHEAD SIGNS TO BE TO BE SET TO INFORM NEIGHBORHOOD TRAFFIC. DETOUR SIGNS WILL BE SET TO NOTIFY RESIDENCES OF CONSTRUCTION ZONE AHEAD
- 2. TEMPORARY STREET PARKING SIGNS SET UP IN THE PUBLIC STREET PARKING ON THE ADJACENT PROPERTIES TO PROVIDE EASY ACCESS FOR TRUCKS TO PARK IN FROM THE PROJECT PROPERTY WITH OUT CAUSE DAMAGE TO NEARBY VEHICLES OR PROPERTY
- 3. DESIGNATED TRUCK PARKING FOR TRUCKS TO BE ON THE STREET PARKING IN FRONT OF THE PROJECT ADDRESS.

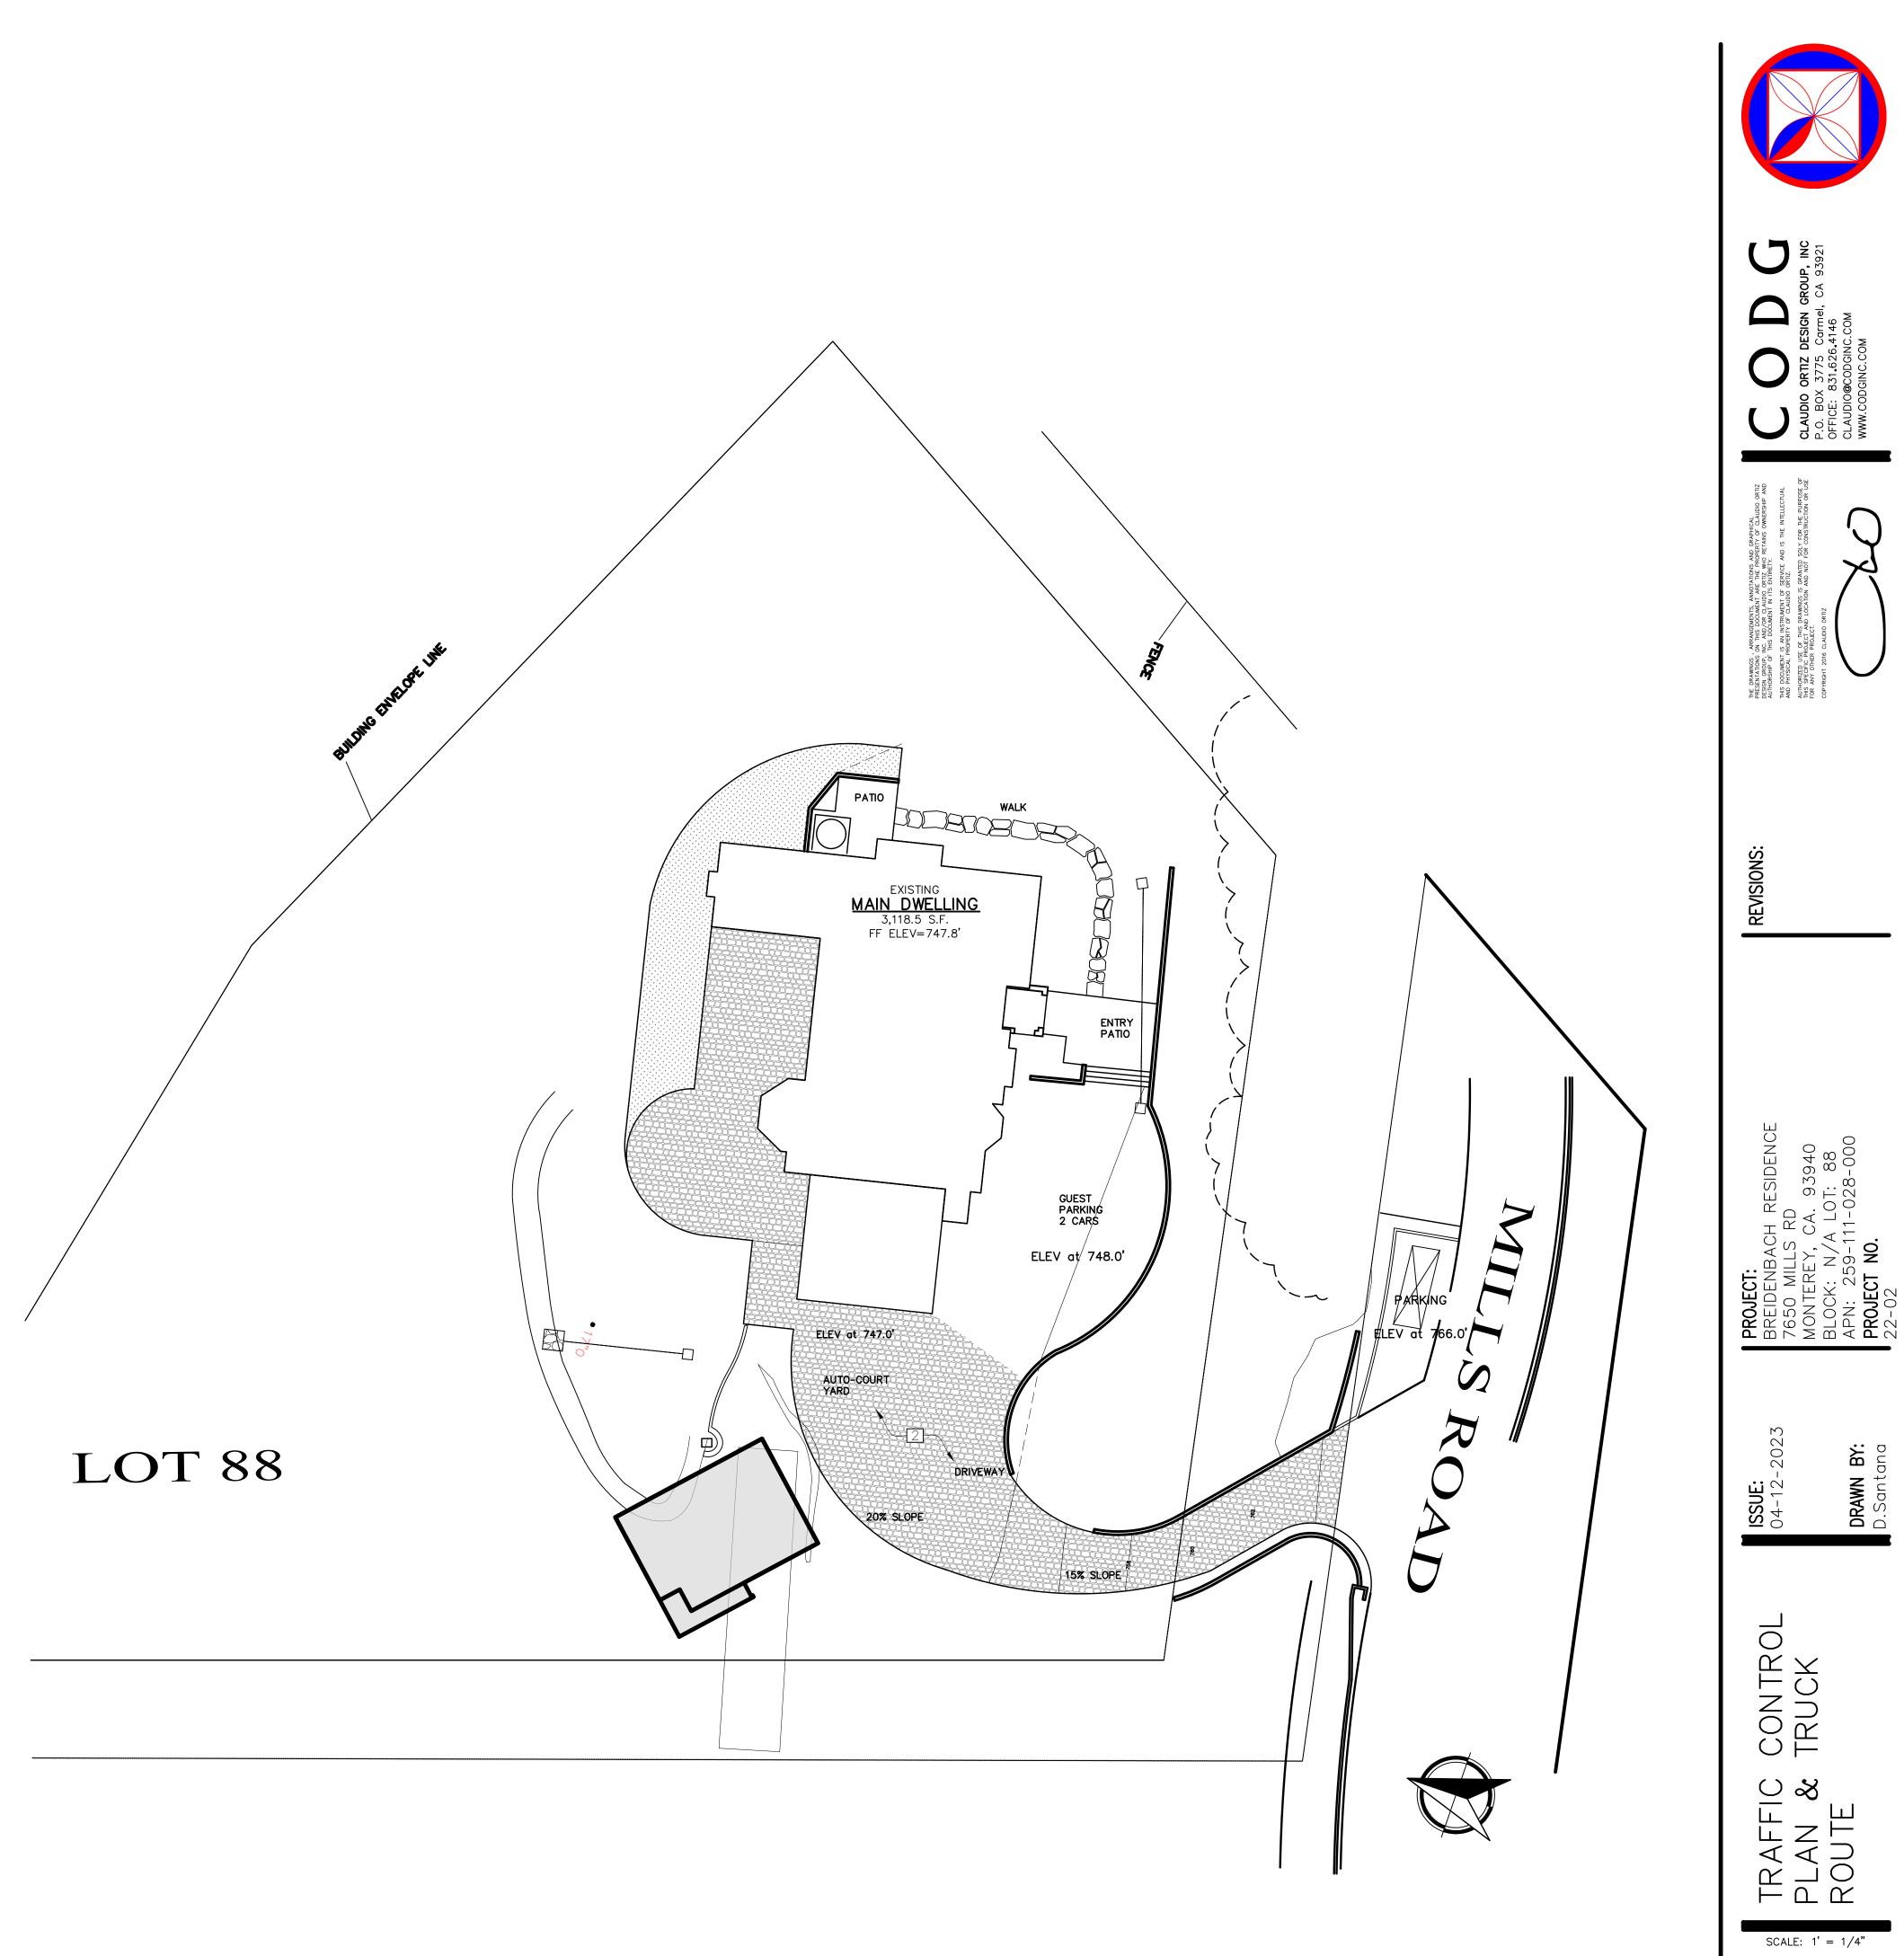

A1.6

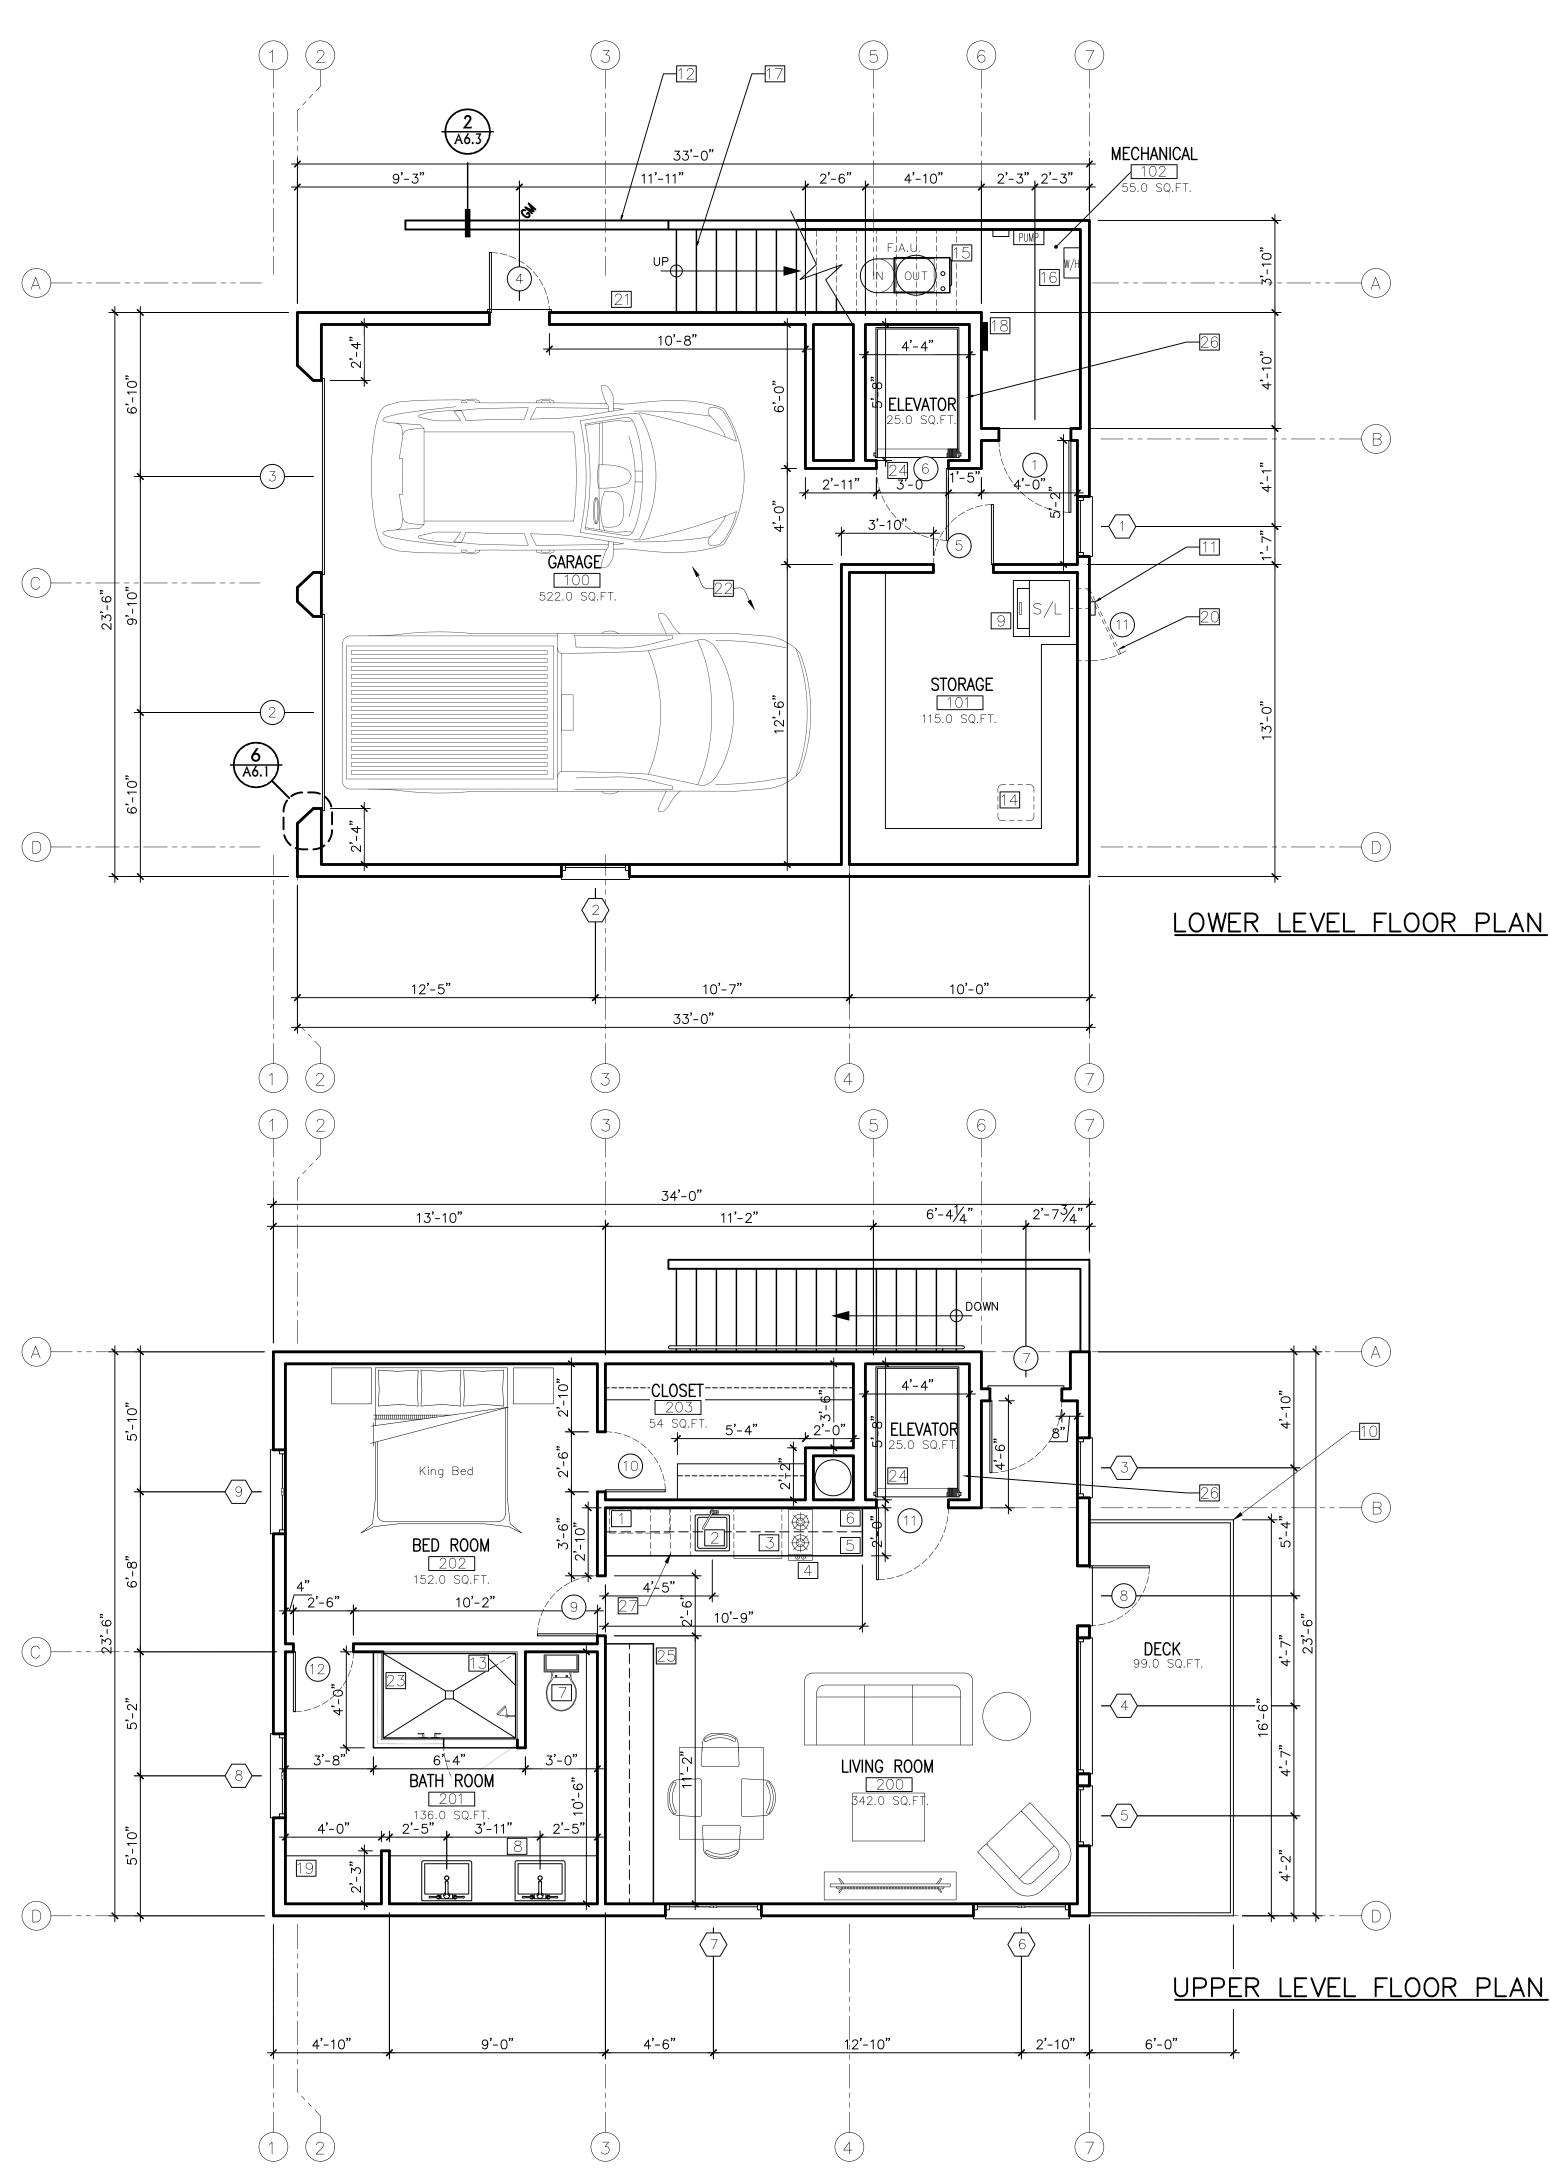

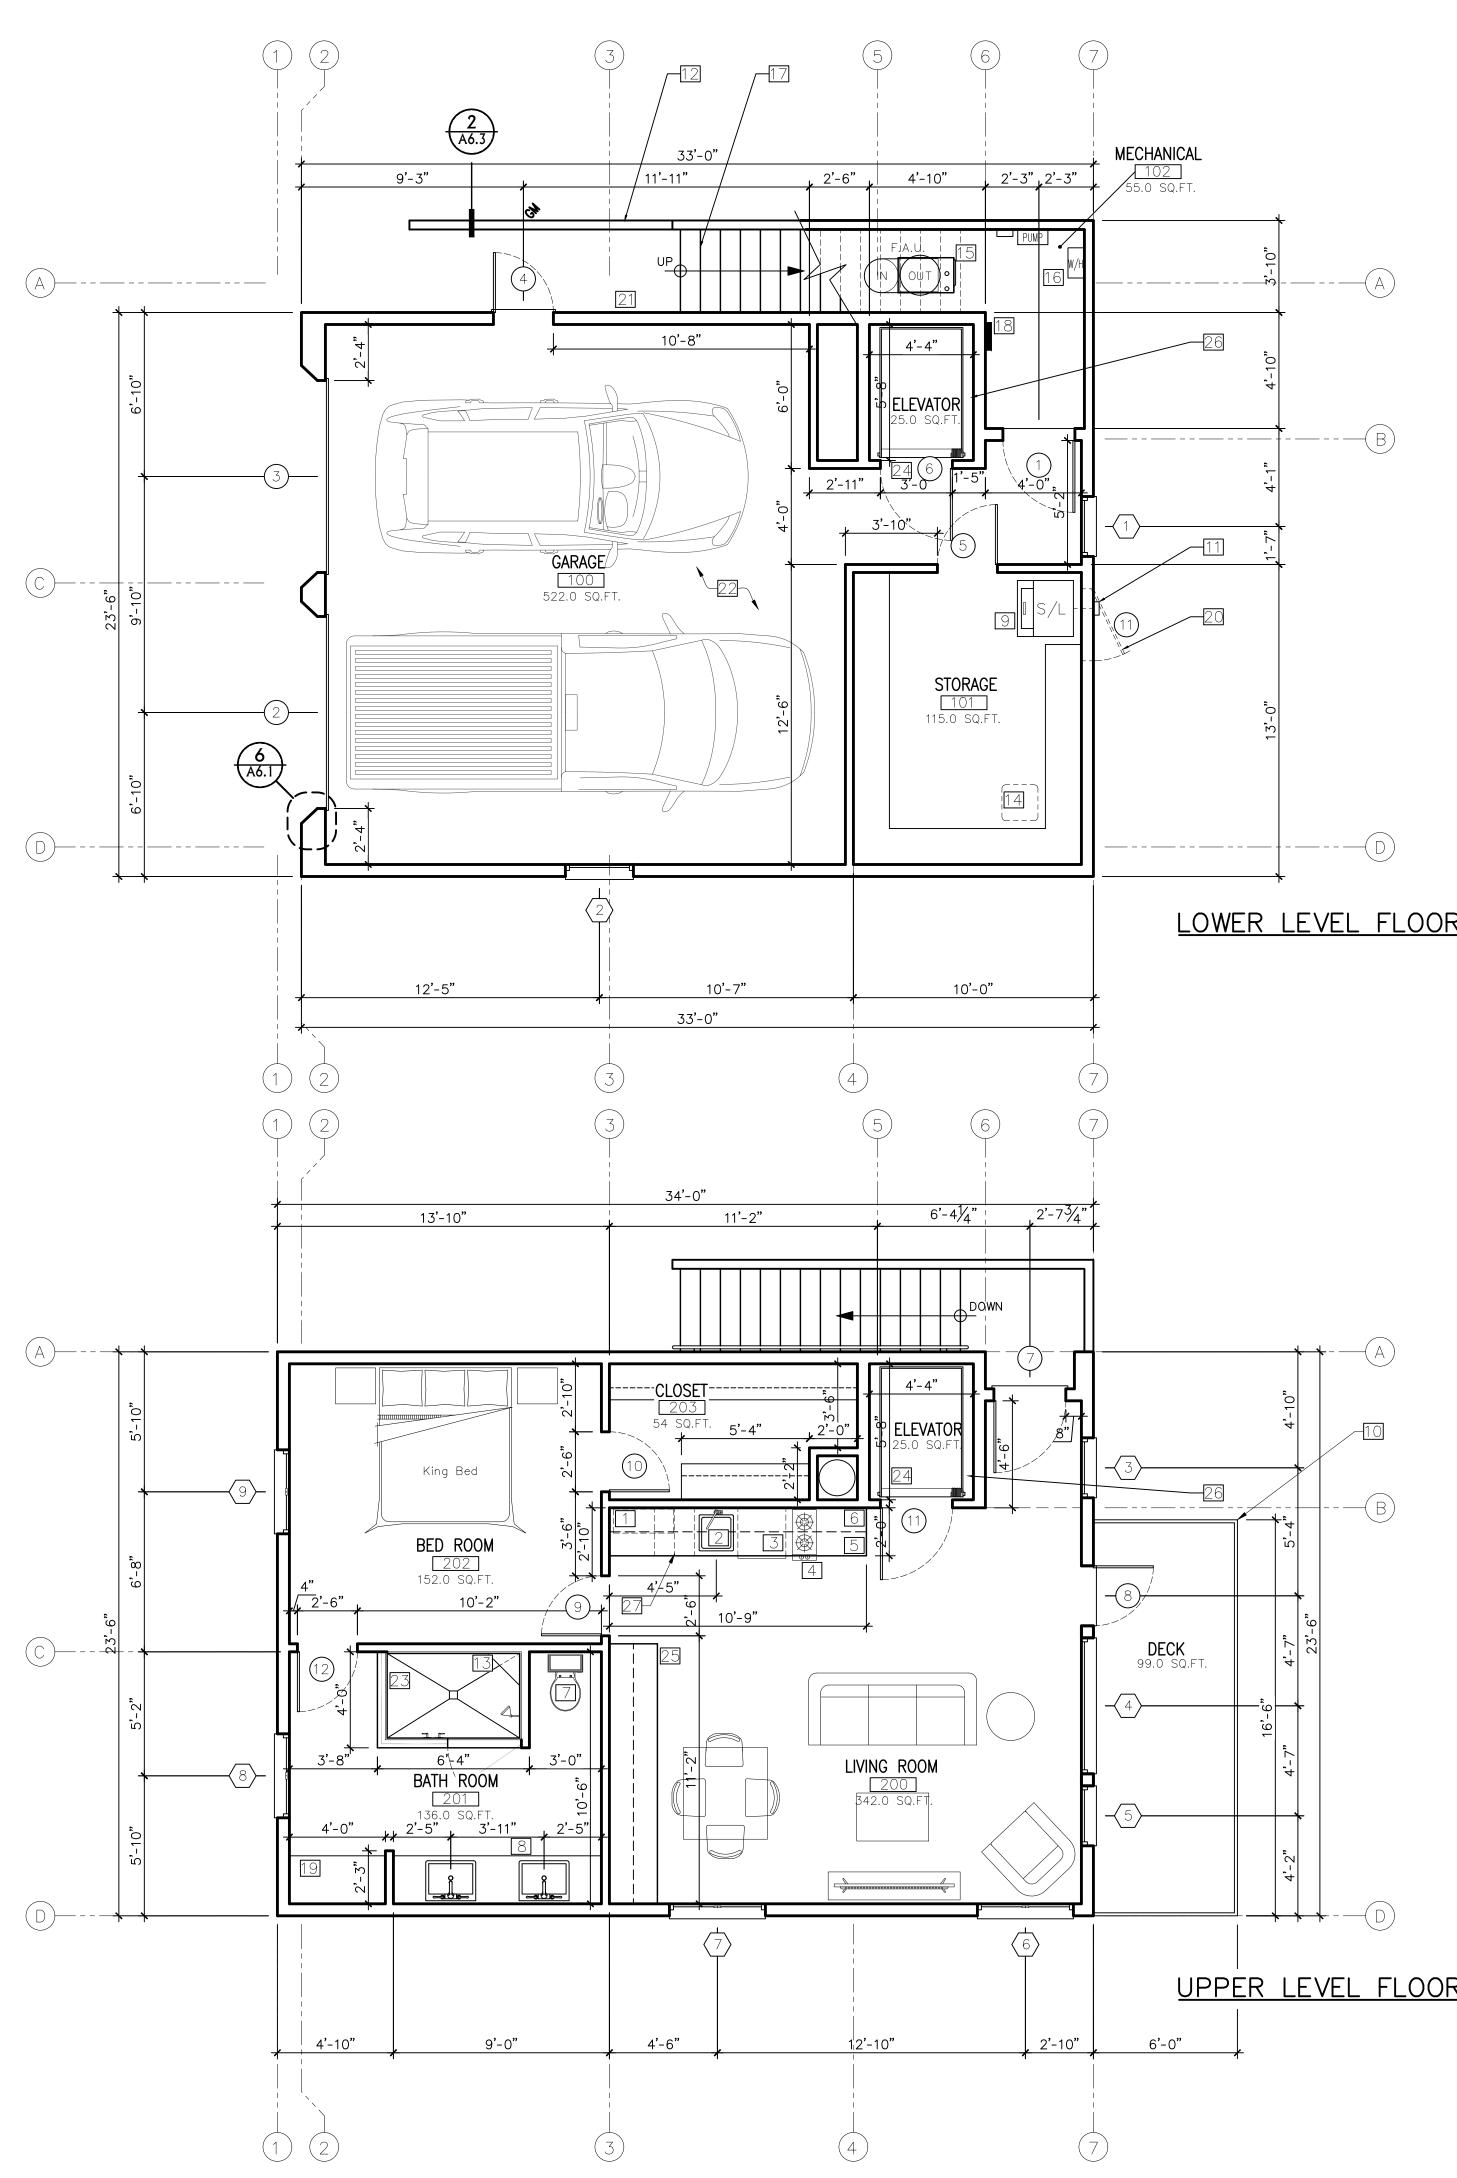

# KEY NOTES

1 NEW MICROWAVE (PLACED IN UPPER CABINETS) 2 NEW KITCHEN SINK

- 3 NEW UNDER COUNTER REFRIGERATOR
- 4 NEW INDUCTION COOKTOP
- 5 NEW 36-INCH HIGH COUNTER TOP WITH BACKSPLASH.
- 6 NEW UPPER CABINETS
- C NEW WATER CLOSET: TO BE MAXIMUM 1.28 GALLONS PER FLUSH PER CPC. 411.2.4
- 8 NEW BATHROOM SINK 36-INCH HIGH W/ OR W/O VANITY WITH STONE TOP AND BACKSPLASH.
- 9 STACKED ELECTRIC WASHER/ DRYER SPACE
- NEW GUARDRAILS: METAL HANDRAIL 42" HIGH OVER METAL BALUSTERS @ 4-INCHES ON CENTER MAX.
   CLOTHES DRYER MOISTURE EXHAUST DUCTS SHALL TERMINATE OUTSIDE THE BUILDING AND HAVE A BACKDRAFT DAMPER. EXHAUST DUCT IS LIMITED TO 14-FEET WITH TWO ELBOWS. THIS SHALL BE REDUCED 2-FEET FOR EVERY ELBOW IN EXCESS OF TWO. SHOW MINIMUM 4-INCHES DIAMETER, SMOOTH METAL DUCT, AND SHOW DUCT POLICE ON PLAN. (CMC 504 4 2) AND SHOW DUCT ROUTE ON PLAN. (CMC 504.4.2) 12 NEW 42" HIGH WALKWAY WALL
- 13 NEW SHOWER BENCH
- NEW HEAT PUMP BELOW IN CRAWL SPACE
- NEW F.A.U. UNDER STAIRS
- NEW GAS TANKLESS WATER HEATER LOCATION
- NEW EXTERIOR STAIRS
- 18 NEW ELEC. SUB PANEL 200 AMPS
- NEW LINEN CABINET FULL HEIGHT
- O NEW 36X60 CRAWLSPACE ACCESS DOOR BELOW
- NEW CONC. WALKWAY
- 22 NEW GARAGE 23 SHOWER PER PLAN
- SHOWER HEAD TO BE 7'-0" FROM FISHED FLOOR
- ANTI-SCALDING VALVE AT SHOWER CONTROL VALVES AND SHOWERHEADS SHALL BE LOCATED ON THE SIDEWALL OF SHOWER COMPARTMENT OR BE OTHERWISE ARRANGED SO THAT THE SHOWERHEAD DOSE NOT DISCHARGE DIRECTLY AT THE ENTRANCE TO THE COMPARTMENT AND THE DIRECTLY AT THE ENTRANCE TO THE COMPARIMENT AND THE BATHER CAN ADJUST THE VALVES PRIOR TO STEPPING INTO THE SHOWER SPRAY. (CPC 408.9). SHOWER-CONTROL VALVES OF THE PRESSURE BALANCE OR THE THERMOSTIC MIXING VALVE TYPE. PER CPC 408.3. DO NOT USE MORE THAN 2.0 GALLONS PER MINUTE PER CPC 408.2
- 24 NEW ELEVATOR
- 25 NEW BUILT IN CABINET
- 26 NEW ELEVATOR SHAFT
- 27 NEW PULLOUT GARBAGE & RECYCLE BINS

LEGEND

(N) WALL


Ν

( IN FEET ) 1/4 inch = 1 ft. GRAPHIC SCALE

EXISTING WALLS TO REMAIN

(N) DECKING


10

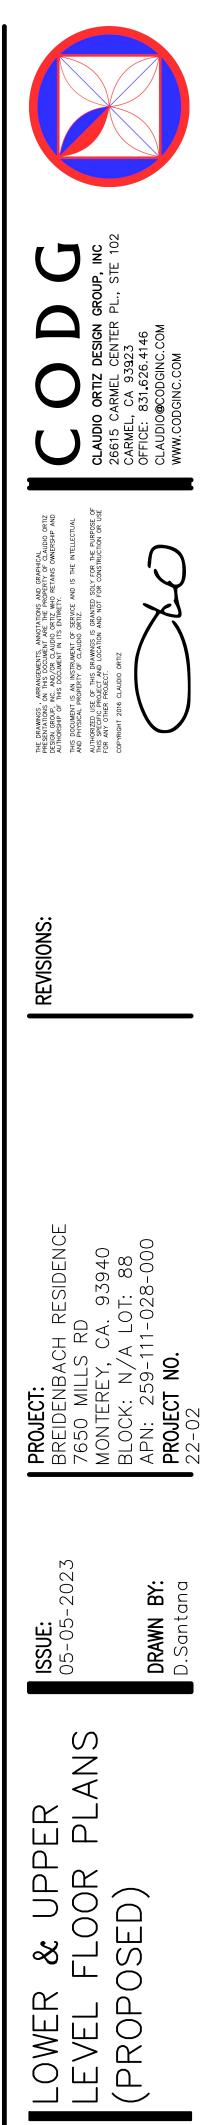



SCALE: 1' = 1/4"

A2.0

15

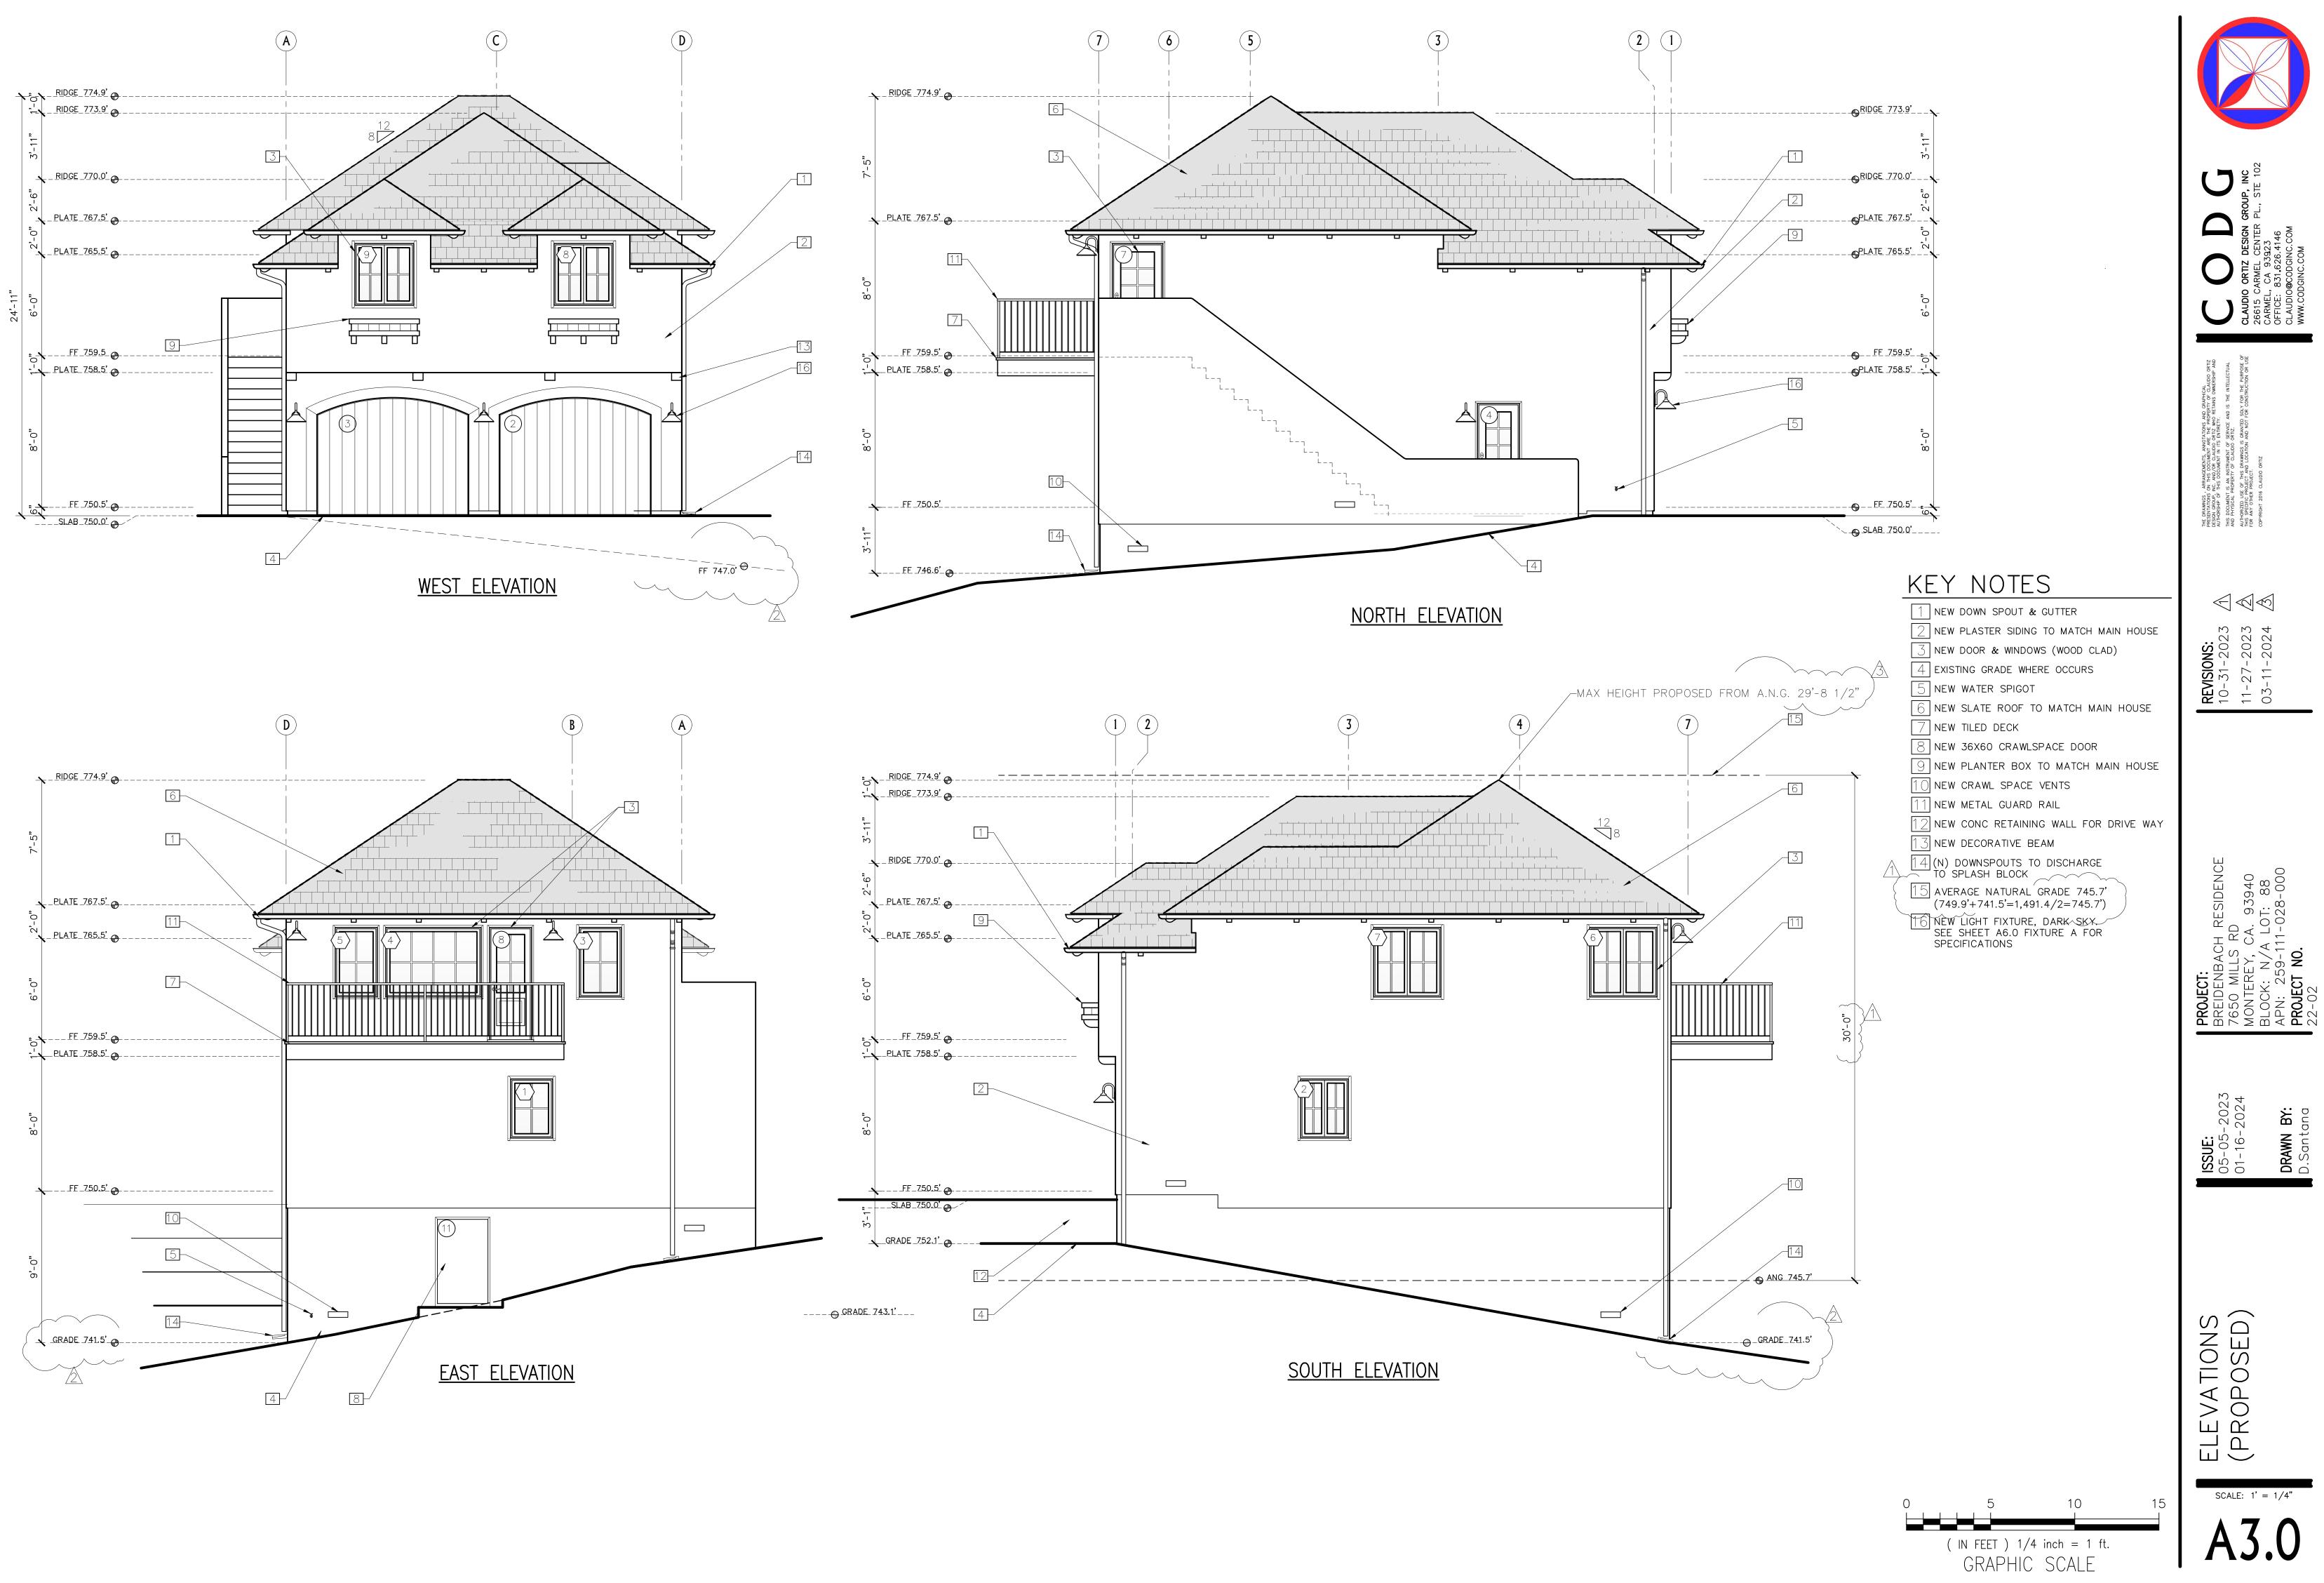

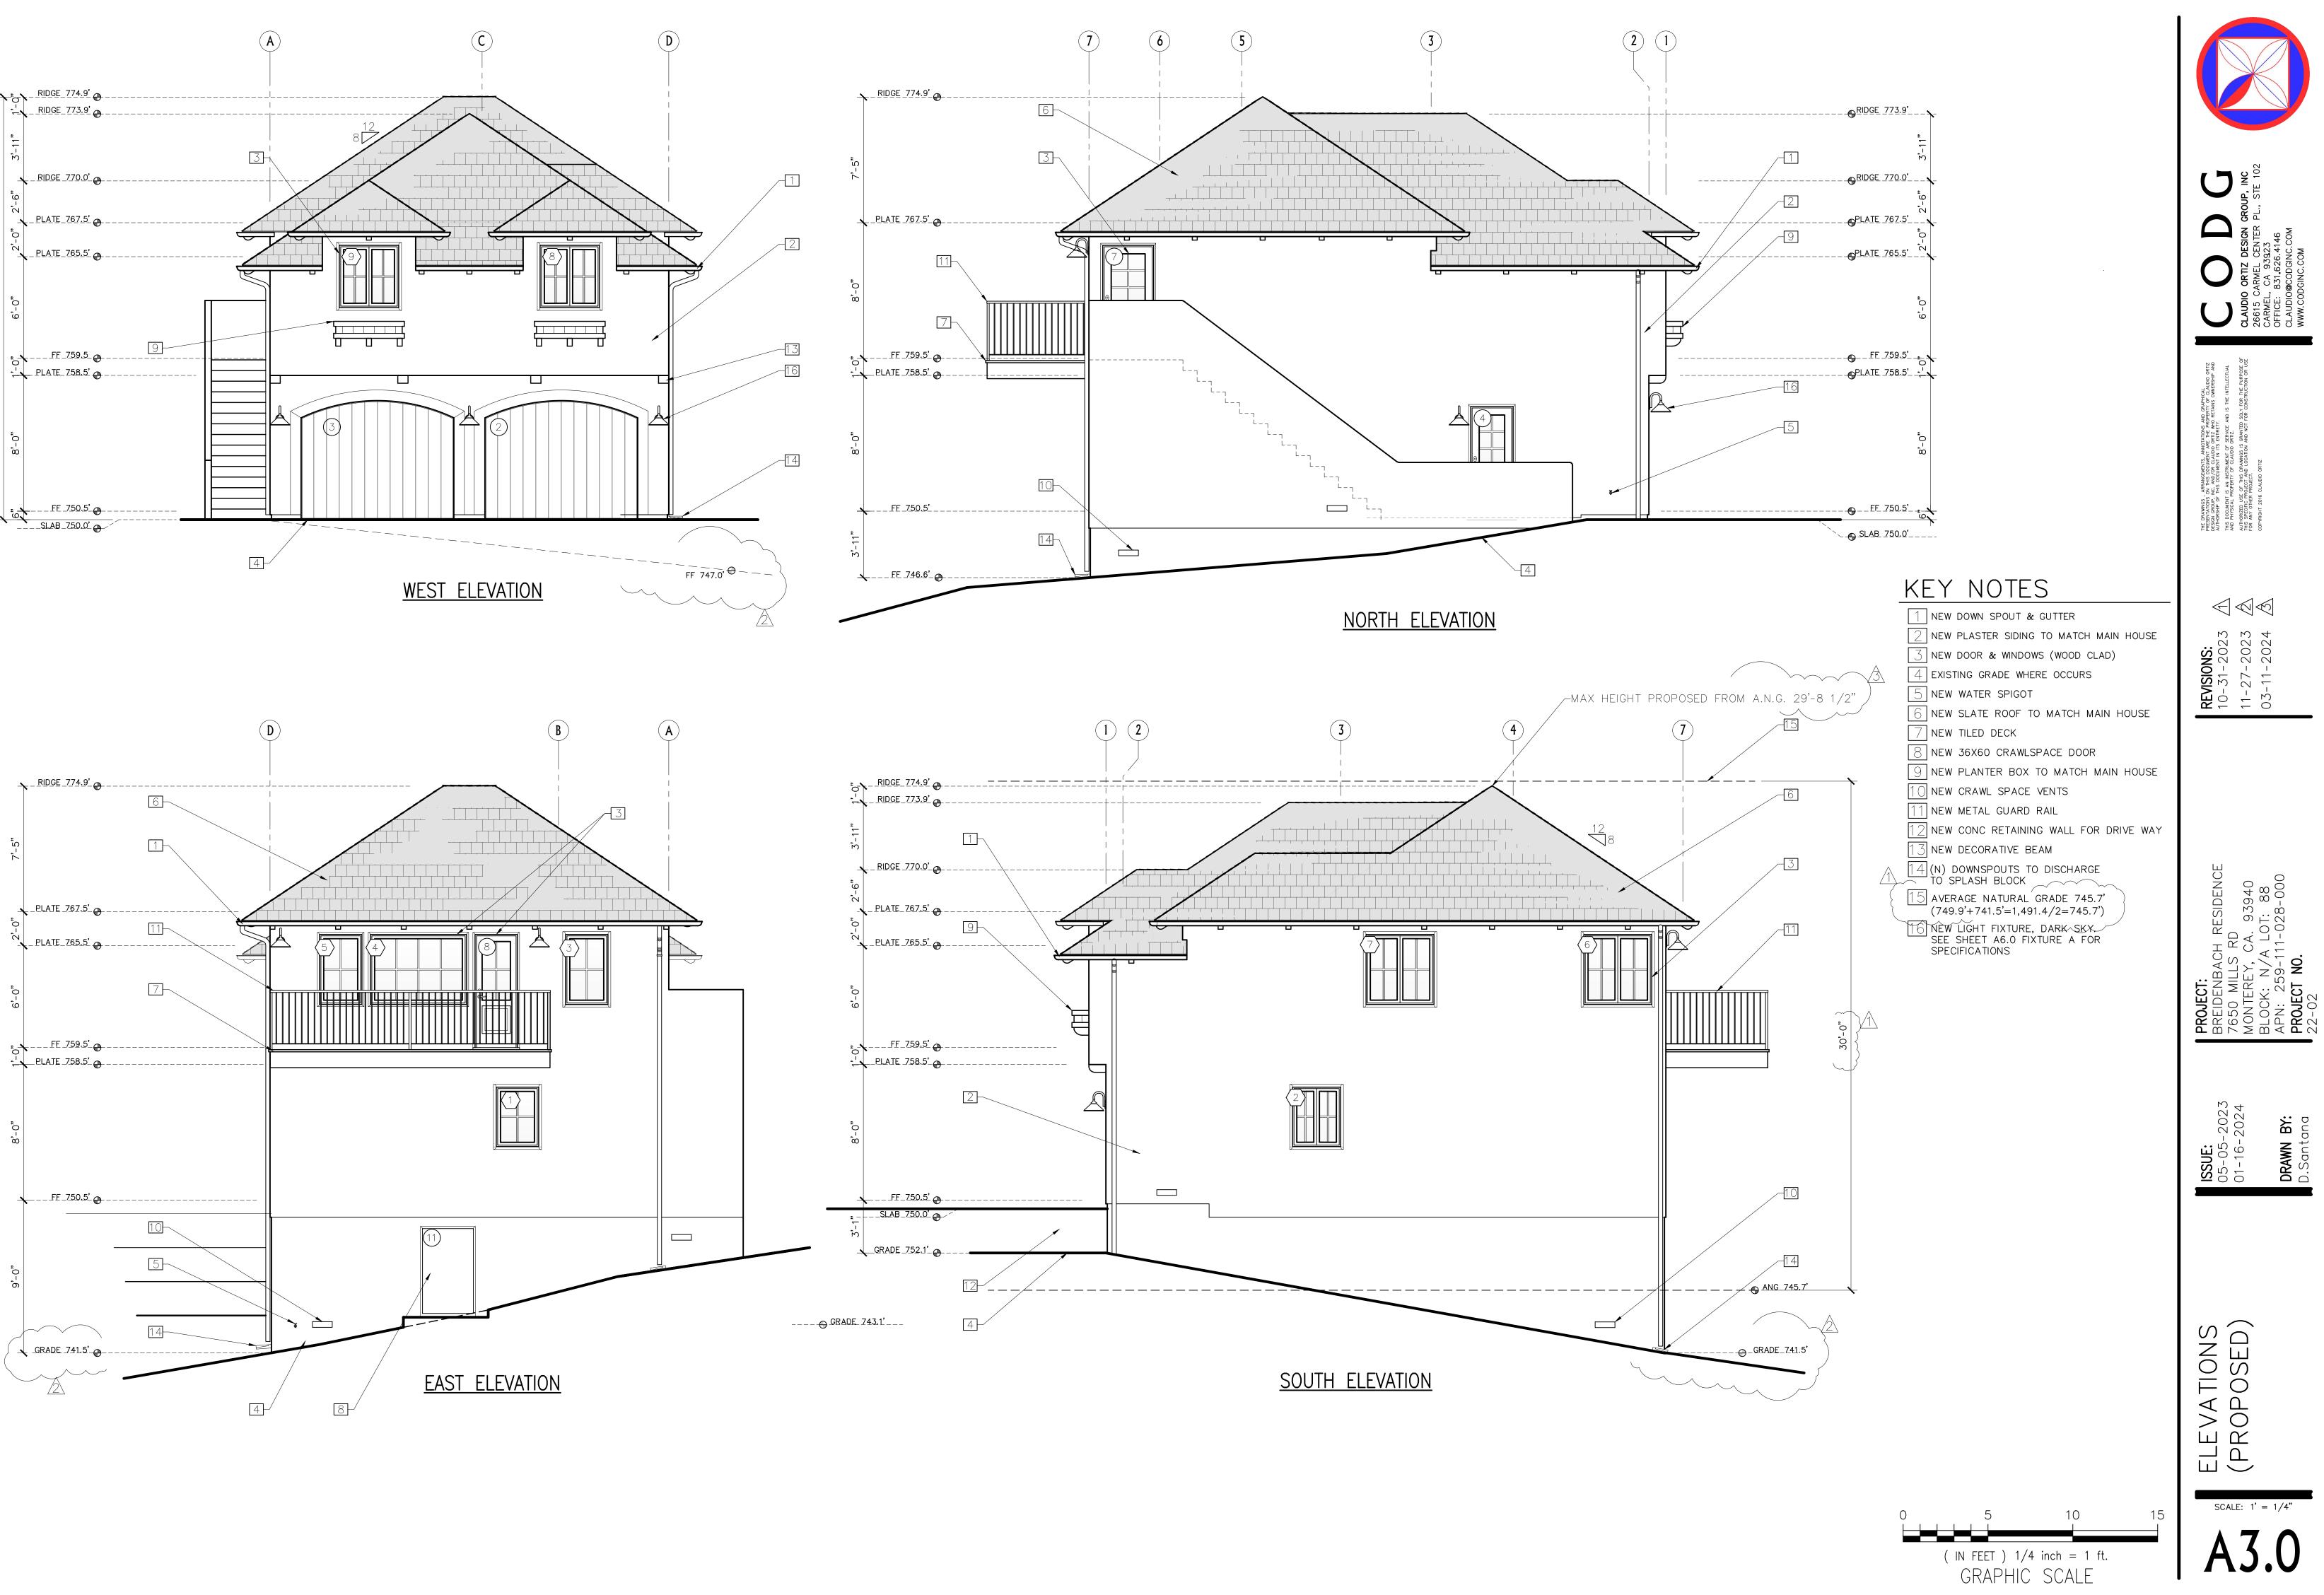

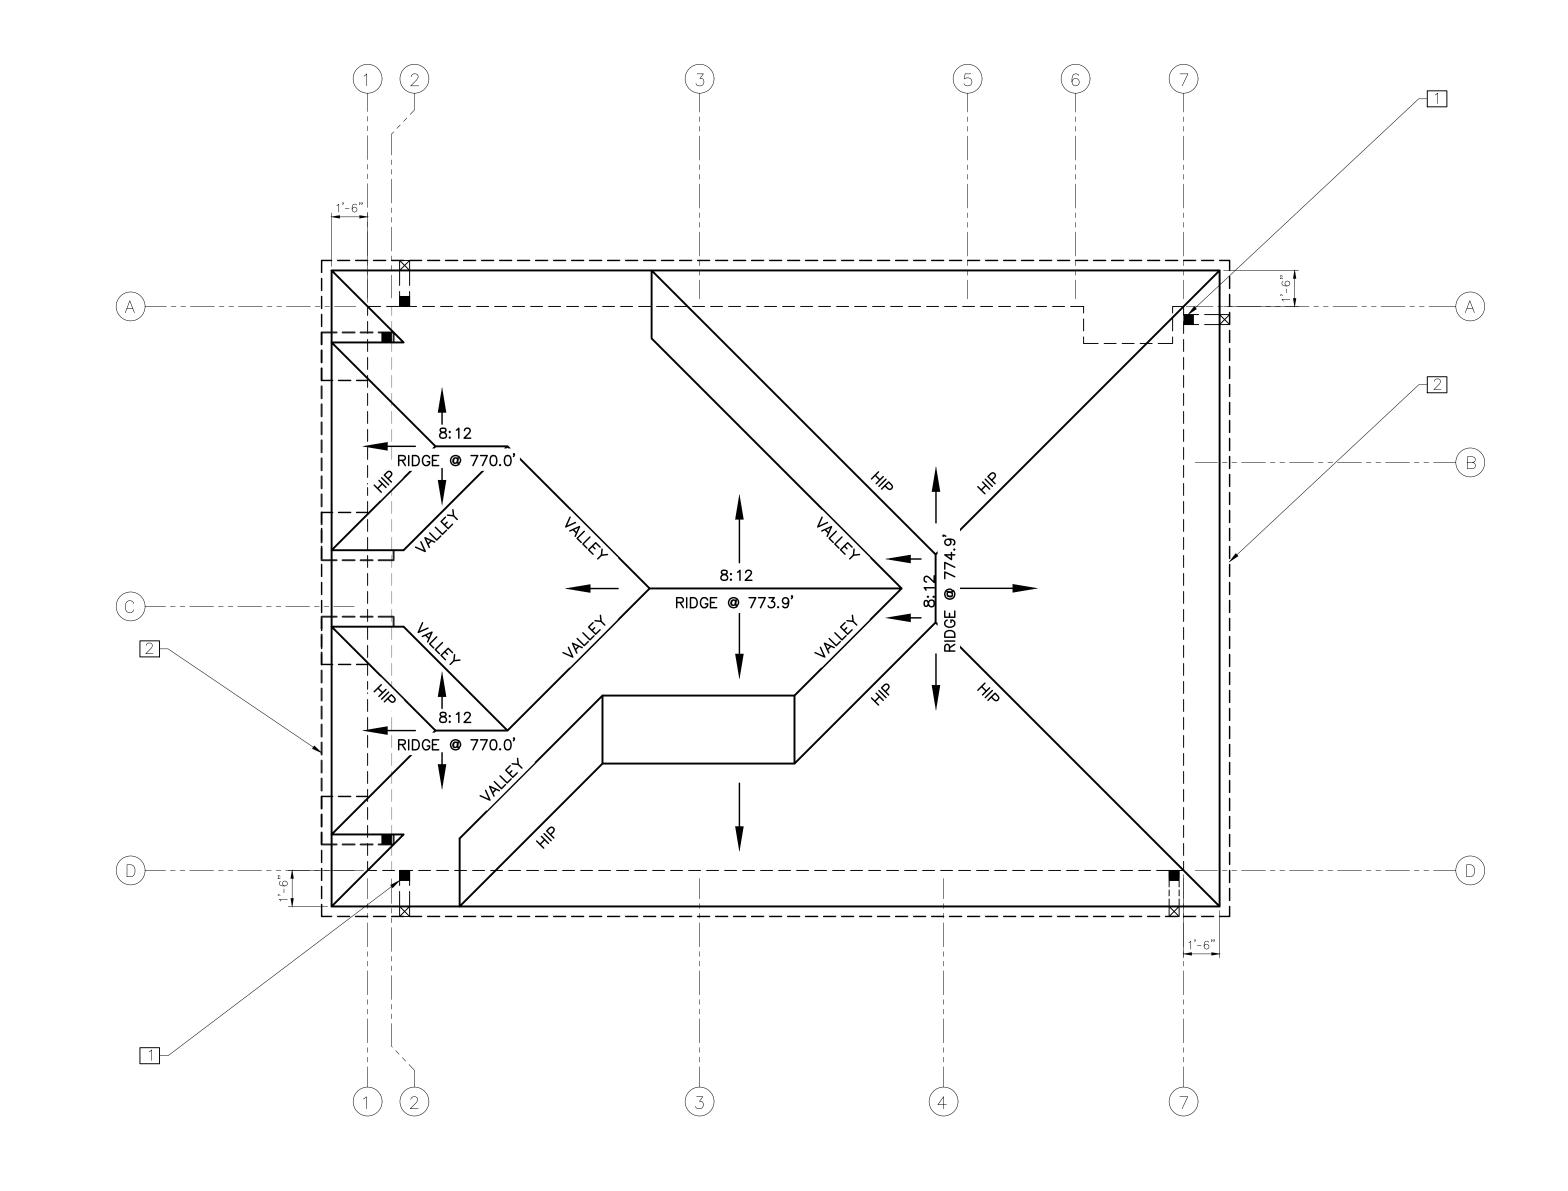

# GENERAL NOTES

- SEE PLAN FOR ROOF SLOPE.
   INSTALLATION OF ROOFING SHALL BE IN ACCORDANCE WITH MANUFACTURE'S SPECIFICATIONS.
- 3. CLASS "A" MINIMUM RATING FOR ROOF ASSEMBLY PER C.B.C 4. IN "CALIFORNIA" DOUBLE FRAMING AREAS PROVIDE OPENINGS INTO MAIN ATTIC SPACE FOR ADEQUATE VENTILATION. PER C.B.C., IF "CALIFORNIA" DOUBLE FRAME AREA HAS MORE THAN 30-INCHES HEADROOM PROVIDE A 22"X30" ACCESS THOUGH MAIN ROOF SHEATHING. VERIFY OPENINGS IN ROOF SHAETHING WITH STRUCTURAL ENGINEER.
- 5. ALL BOX COLUMNS AND 'POP-OUTS' SHALL REMAIN OPEN AT TOP PALET LINE TO ALLOW FOR VENTILATION. PROVIDE TWO (2) LAYERS GRADE "D" MINIMUM PAPER UNDER STUCO WHERE WOOD SHEATHING ACCURS. 6. PROVIDE DRAFT STOPS PER C.B.C
- 7. ALL ROOF FASTENERS TO BE CAPABLE OF RESISTING WIND LOAD OF 110 M.P.H. INSTALLED PER MANUFACTURER'S WRITTEN INSTRUCTION.. (As shown
- in Figured R301.2(4)A.)
  8. BUILT UP ROOFING TO HAVE MINERAL SURFACE CAP SHEET WITH FIBERGLASS BASE SHEET SPOT MOPPED TO DECK. PROVIDE 2 FIBERGLASS PLYSHEETS WITH TYPE III ASPHALT @ 25-30. CONSULT MANF. FOR SPECIFIC INSTALLATION DECUMPENDENTS. REQUIREMENTS.
- 9. WHERE CEILING ARE APPLIDE TO UNDER-SIDE OF ROOF RAFTERS, EACH SEPARATE SPACE SHALL HAVE CROSS VENTILLATION OPENING & MINIMUM 1-INCH AIR SPACE BETWEEN INSULATION AND ROOF SHEATHING. 10. FLAT ROOFS MUST SLOPE A MINIMUM OF 1/4-INCH PER FOOT FOR DRAINAGE
- OR SUBMIT DESING TO SUPPORT ACCUMULATED WATER. (Sec. 1611.2) 11. 50% OF THE REQUIRED VENTILATION AREA SHALL BE PROVIDED BY VENTILATORS IN THE UPPER PORTION OF THE SPACE TO BE VENTILATED AT

LEAST 3-FEET ABOVE EAVE OR CORNICE VENTS WITH THE BALANCE.


# KEY NOTES


1 DOWNSPOUTS

2 GUTTERS W/ 2% SLOPE


LEGEND

<b></b>	SLOPE DIRECTION ARROW
	ROOF LINE: NEW THICK SOLID LINE
	BUILDING FOOTPRINT THIN DASHED LINE
	GUTTERS
	DOWNSPOUTS W/2% SLOPE

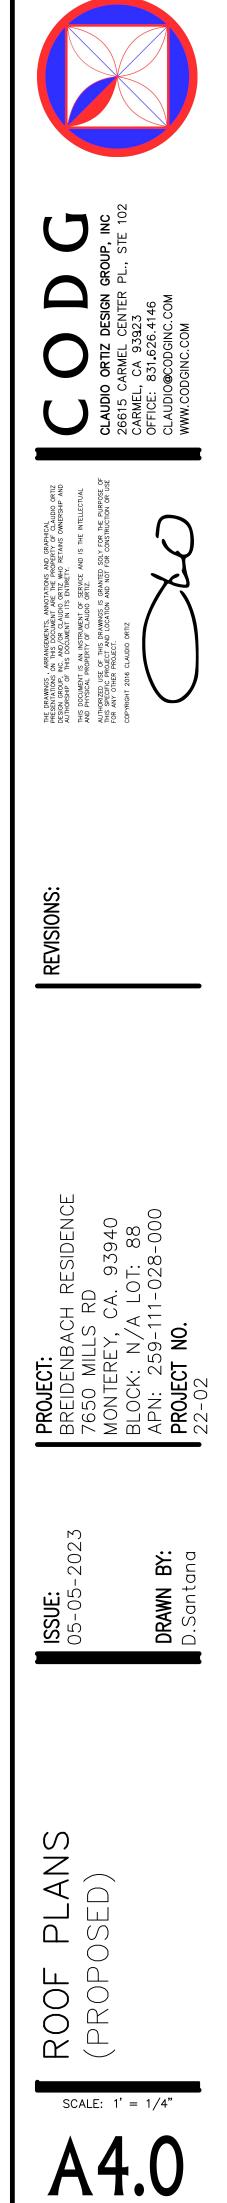

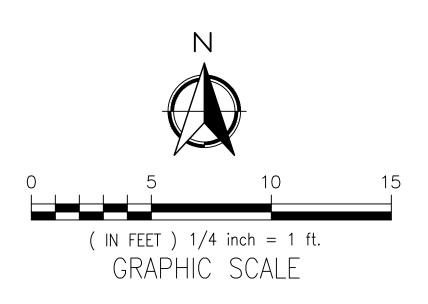


(1) (2)1 7 (C)-----(D)----- $(1) \quad (2)$ A----- $\mathcal{H}$ 5  $\neq$  $\neq$ 6

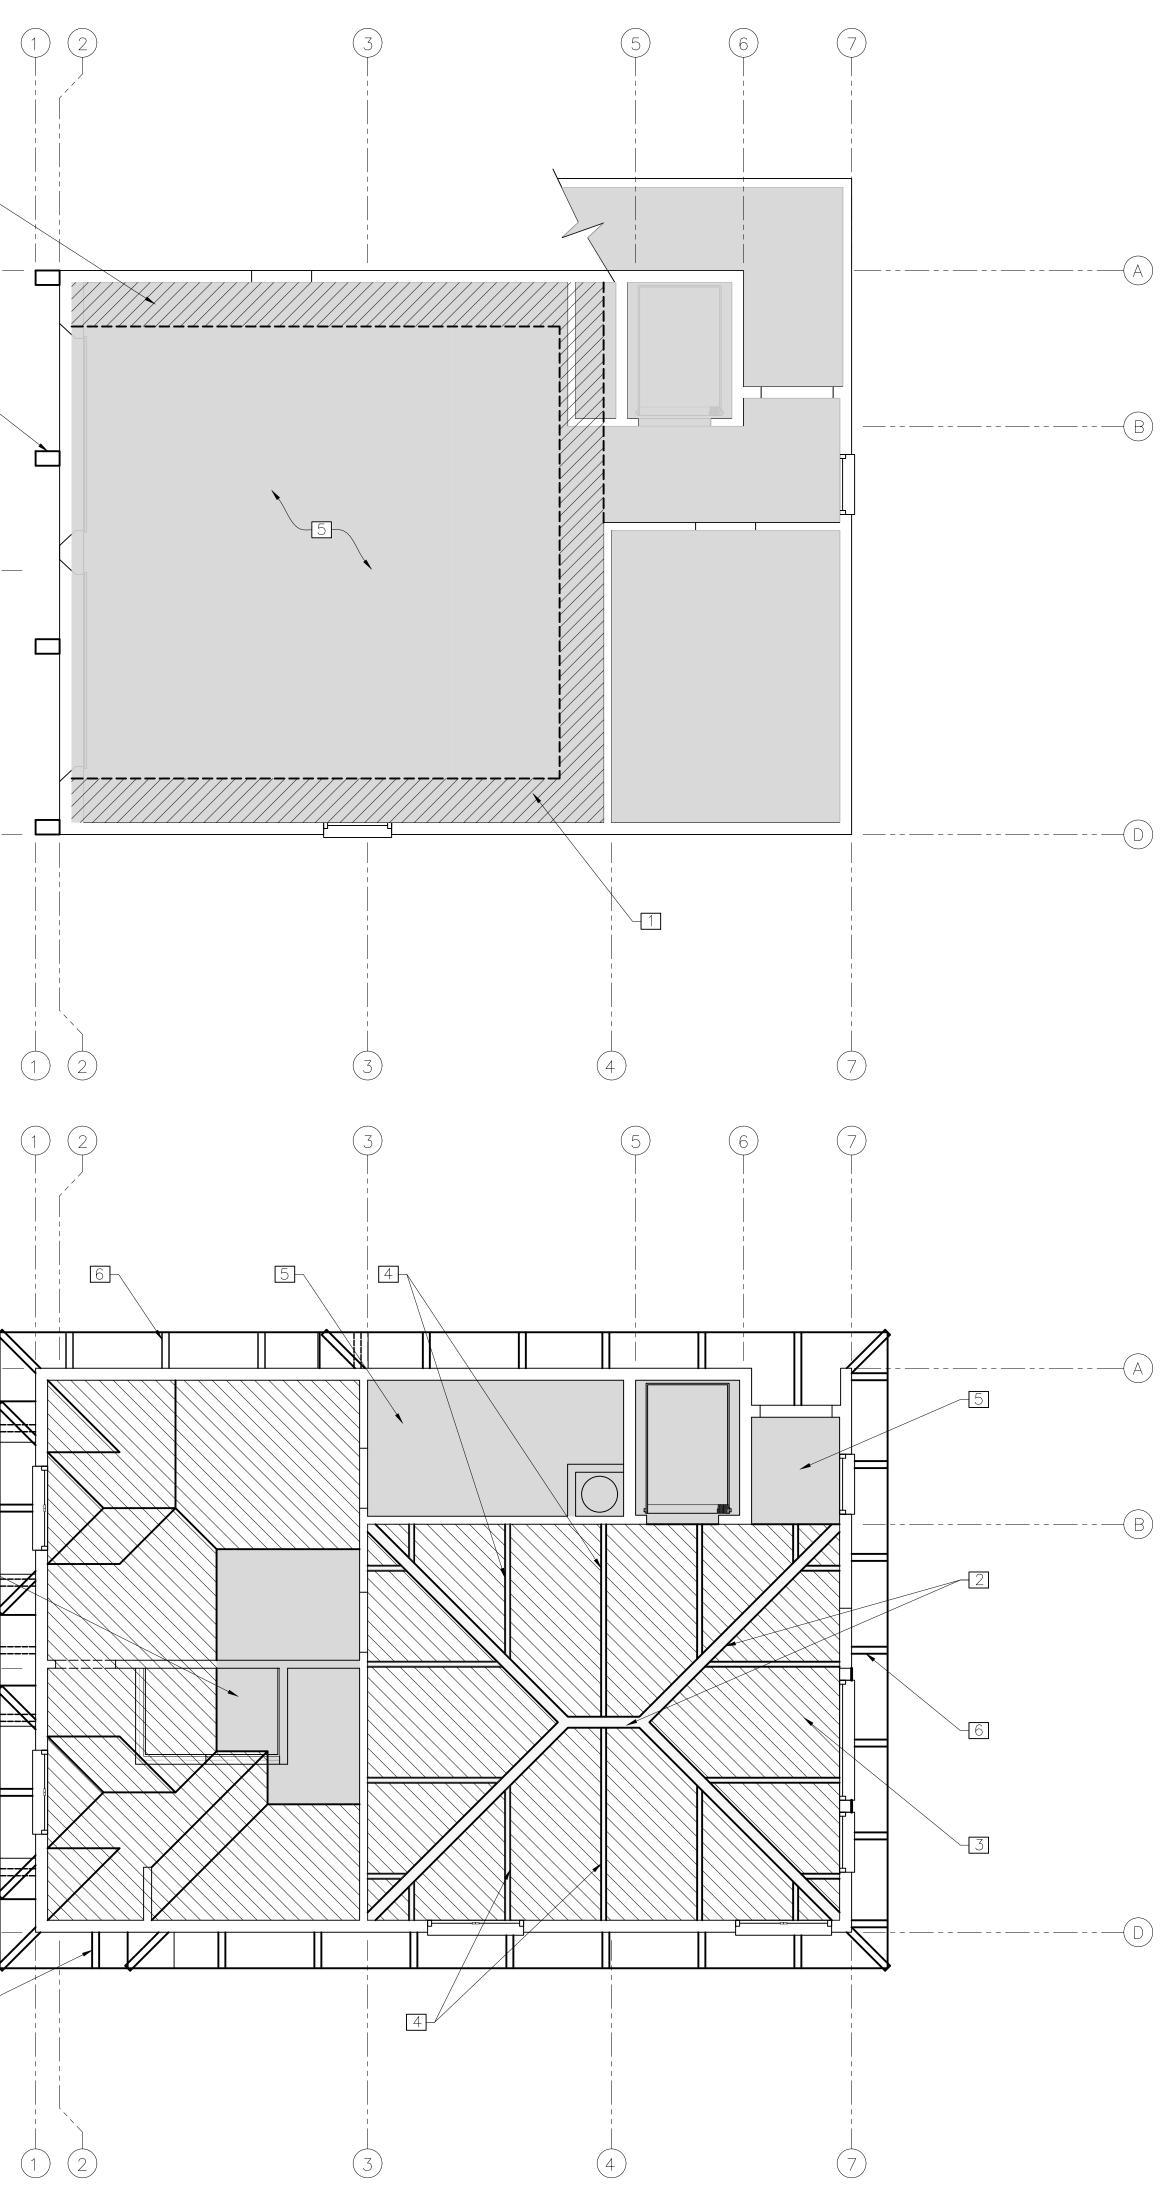

KEY NOTES SOFFIT SHOWN CROSS HATCHED 2 6X6 RD. WD. RAFTER STAINED 3 SLOPED OPEN BM. CEILING 4 3X4 RD. WD. BM. 5 FLAT CEILING 5/8-INCH TYPE "X" 6 4X8 RAFTER TAILS @ 48" O.C 7 DECORATIVE BM

# LEGEND

 

WOOD BEAMS



SLOPED OPEN CEILING





SOFFIT


# AL PRE VBACH RESIDENC IILLS RD EY, CA. 93940 N/A LOT: 88 59-111-028-000 **NO.** PROJECT: BREIDENB. 7650 MILI MONTEREV MONTEREV APN: 256 APN: 256 22-02

# NOTES:


- All beams and decking to be kiln-dry lumber.
   Drywall 5/8" thick gypsum board typical.
   GARAGE TO DWELLING SEPARATION: The private garage shall be separated from the dwelling unit and its attic area by means of gypsum board, not less than 1/2 inch (12.7 mm) in thickness, applied to the garage side. Garages beneath habitable rooms shall be separated from all habitable rooms above by not less than a 5/8-inch (15.9 mm) Type X gypsum board or equivalent and 1/2-inch (12.7 mm) gypsum board applied to structures supporting the separation from habitable rooms above the garage. (CRC R302.6)
- structures supporting the separation from habitable rooms above the garage. (CRC R302.6)
  Door openings between a private garage and the dwelling unit shall be equipped with either solid wood doors or solid or honeycomb core steel doors not less than 13/8 inches (34.9 mm) in thickness, or doors in compliance (CRC R302.5.1) with a fire protection rating of not less than 20 minutes. Doors shall be self-closing and self-latching.

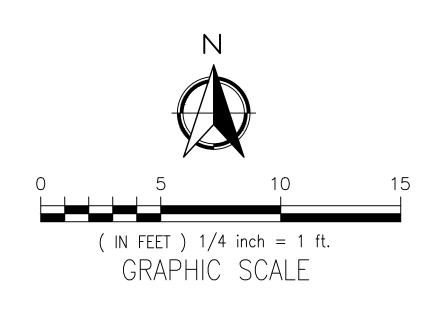

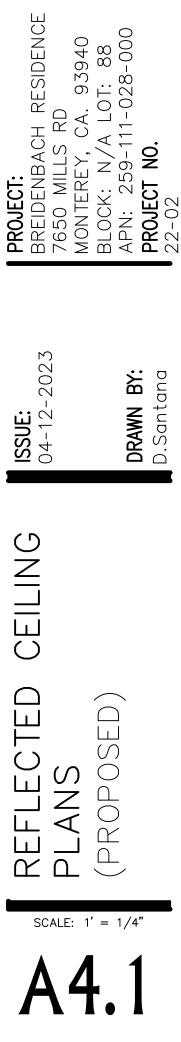

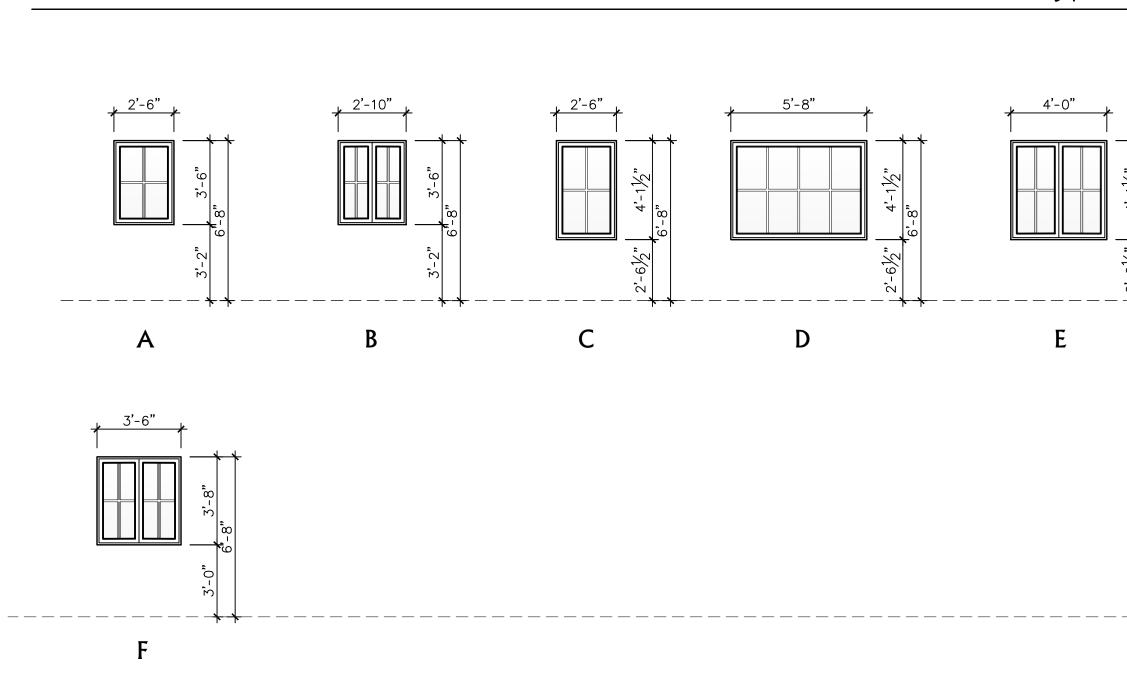

\_\_\_\_\_\_\_

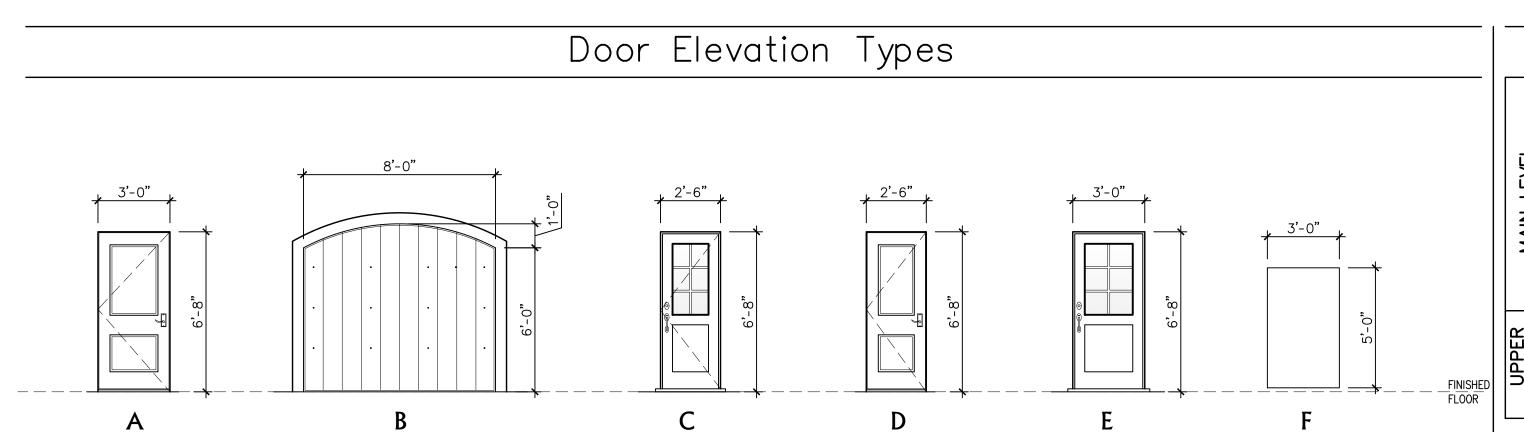

Window Elevation Types				Window S	Sche	dule					
$\begin{array}{c} 5'-8'' \\ \hline \\$	<b>H H H H H H H H H H</b>	LOCATION GARAGE GARAGE LIVING ROOM LIVING ROOM LIVING ROOM	B C D C	2'-6" X 3'-6" 2'-10" X 3'-6" 2'-6" X 4'-1 1/2" 5'-8" X 4'-1 1/2" 2'-6" X 4'-1 1/2"	P P P P P	REMARKSCASEMENTCASEMENTCASEMENTFIXEDCASEMENT	MATERIALWOOD-UNCLADWOOD-UNCLADWOOD-UNCLADWOOD-UNCLADWOOD-UNCLADWOOD-UNCLAD	YES YES YES YES	YES YES YES YES YES	NONNONYESNNON	NO NO NO NO NO
	FINISHED FLOOR FLOOR FINISHED FLOOR FINISHED FINISHED 	LIVING ROOM LIVING ROOM BATH ROOM BED ROOM	E F	4'-0" X 4'-1 1/2" 5'-0" X 4'-1 1/2" 3'-6" X 3'-8" 3'-6" X 3'-8"	P P	CASEMENT CASRMENT CASEMENT CASEMENT	WOOD-UNCLAD WOOD-UNCLAD WOOD-UNCLAD WOOD-UNCLAD	YES YES	YES YES YES	NO NO	10 10 10 10
	FINISHED FLOOR										
	-										

				Door Sche	dul	е
LEVEL	NO.	LOCATION	ТҮРЕ	SIZE	FINISH	REMARKS
	1	MECHANICAL	А	3'-0" X 6-8"	Р	FLUSHED / PANELED DOOF
MAIN	2	GARAGE	В	8'-0" X 7'-0"	Р	ROLL-UP WD ARCHED GAR.
۸A	3	GARAGE	В	8'-0" X 7'-0"	Ρ	ROLL-UP WD ARCHED GAR
—	4	GARAGE	С	2'-6" X 6'-8"	Ρ	GLASS / PANELED DOOR
	5	GARAGE/STORAGE	D	2'-6" X 6'-8"	Р	FLUSHED / PANELED DOOF
	6	GARAGE/ELEVATOR	А	3'-0" X 6'-8"	Р	FLUSHED / PANELED DOOF
~	7	LIVING ROOM	E	3'-0" X 6-8"	Р	GLASS / PANELED DOOR
	8	LIVING ROOM	С	2'-6" X 6'-8"	Р	GLASS / PANELED DOOR
UPPER	9	BED ROOM	D	2'-6" X 6'-8"	Р	FLUSHED / PANELED DOOF
55	10	CLOSET	D	2'-6" X 6'-8"	Р	FLUSHED / PANELED DOOF
	11	CRAWLSPACE	F	3'-0" X 5'-0"	Р	FLUSHED

# Door Notes:

- 1. PROVIDE DEAD BOLT LOCKS ON ALL EXTERIOR DOORS. SEE SCHEDULE FOR ADDITIONAL REQUIREMENTS.
- 2. PROVIDE PRIVACY HARDWARE FOR ALL BEDROOM AND BATHROOM LOCATIONS.
- 3. GENERAL CONTRACTOR TO CONSULT WITH OWNER FOR ADDITIONAL DOOR HARDWARE REQUIREMENTS.
- 4. ALL DOOR GLAZING TO BE TEMPERED GLASS.
- 5. ALL EXTERIOR DOOR GLAZING TO BE 5/8" INSULATED TEMPERED GLASS.
   6. DOORS BETWEEN CONDITIONED AND UNCONDITIONED
- SPACES TO BE FULLY WEATHER STRIPPED.7. GENERAL CONTRACTOR TO REVIEW DOOR ORDER WITH ARCHITECT PRIOR TO DOOR ORDER PLACEMENT.
- 8. DOOR HINGES TO BE 4.5"H.X4.5"W. DOOR 7'-0"
- 9. ALL DOOR TOPS AND BOTTOM TO BE SANDED, FINISHED. AND SEALED.
   10. GARAGE DOORS :
- SEE SCHEDULE AND EXTERIOR ELEVATIONS FOR ADDITIONAL INFORMATION.
- 11. THE DOOR FINISH PER CLIENT OR CODG, INC.
- 12. THE DOOR STILES TO BE PER PLAN 13. CHECK FLOOR PLAN FOR HINGES LOCATION
- 14. PER THE ENERGY CODE ALL WINDOWS ARE TO BE LAMINATED DOUBLE GLAZING PANE.

## Window Notes:

- PROVIDE SAFETY GLAZING (TEMPERED OR LAMINATED) AS REQUIRED PER C.B.C.
   SCREEN COLOR TO BE SPECIFIED BY CLIENT
- 3. GENERAL CONTRACTOR TO VERIFY THE WINDOW ORDER AND ROUGH FRAMING WITH THE DESIGNER/ARCHITECT PRIOR TO PLACEMENT OF THE WINDOW ORDER.
- THE WINDOW MANUFACTURER WILL SUPPLY SHOP DRAWINGS FOR SPECIAL WINDOWS (OVERSIZE,ETC.) FRO REVIEW BY CODG, Inc.
- 5. APPLY SISAL KRAFT PAPER AROUND ALL EXTERIOR OPENING.
   6. PROVIDE CONTINUOUS CAULK AROUND ALL WINDOW
- OPENINGS WITH G.E. SILICONE ACRYLIC, POLYSULFIDE OR URETHANE AS REQUIRED. 7. ALL MANUFACTURED WINDOWS TO BE CERTIFIED AND
- ALL MANUFACTURED WINDOWS TO BE CERTIFIED AND LABELED MEETING STANDARDS LISTED IN TABLE 2-53V OF TITLE 24.
   EXTERIOR WINDOW FINISH TO BE SEALED, U.N.O.
- EXTERIOR WINDOW FINISH TO BE SEALED, U.N.C
   ALL OPERABLE WINDOWS TO HAVE SCREENS.
- AS SPECIFY BY CLIENT. 10. SEE EXTERIOR ELEVATIONS FOR ALL WINDOW HEAD
- HEIGHTS. 11. DOUBLE PANE LAMINATED GLASS
- AS SPECIFIED TITLE. 24 GLASS & GLAZING SEC. 2401 & TABLE 2403.2.1
- 12. PER THE ENERGY CODE ALL WINDOWS ARE
- TO BE GLAZING AS DUAL PANE. 13. WINDOW JAMS TO BE 3-1/2-INCHES WITHOUT EXTESION JAMS AND DELIVERED WITH EXTERIOR WOOD SILLS ONLY. (U.N.O)


### Note:

- 1. FOR HINGE LOCATION & OPENING SWING DIRECTION
- SEE ELEVATIONS 2. ALL WINDOW DIMENSIONS ARE THE ROUGH OPENING
- SEE ELEVATIONS 3. ALL DOOR DIMENSIONS ARE ACTUAL DOOR SIZE & OPENING SEE ELEVATIONS

# Tempered Glass Note:

- EACH PANE OF GLAZING INSTALLED IN HAZARDOUS LOCATIONS SHALL BE TEMPERED GLASS; THE FOLLOWING LOCATIONS SHALL BE HAZARDOUS LOCATIONS FOR GLAZING: A) GLAZING IN DOORS.
- B) GLAZING IN A FIXED OR OPERABLE PANEL ADJACENT TO A DOOR WHERE THE BOTTOM OF THE GLAZING IS LESS THAN 60-INCHES ABOVE THE FLOOR OR WALKING SURFACE AND ITS EITHER WITHIN 24-INCHES OF EITHER SIDE OF THE DOOR IN THE PLANE OF THE DOOR "OR" WHERE THE GLAZING IS ON A WALL PERPENDICULAR TO THE PLANE OF THE DOOR WITHIN 24-INCHES OF THE HINGE SIDE OF AN IN-SWINGING DOOR.
- C) GLAZING IN WINDOWS THAT MEET ALL THE FOLLOWING CONDITIONS:
- 1. THE EXPOSED AREA OF AN INDIVIDUAL PANE IS LARGER THAN 9 SQUARE FEET.
- 2. THE BOTTOM EDGE OF THE GLAZING IS LESS THAN 18-INCHES ABOVE THE FLOOR.
- 3. THE TOP EDGE OF THE GLAZING IS LESS THAN 18-INCHES
- ABOVE THE FLOOR. 4. ONE OR MORE WALKING SURFACES ARE WITHIN 36-INCHES,
- MEASURED HORIZONTALLY. D) GLAZING IN GUARDS AND RAILINGS.
- E) GLAZING IN WALLS CONTAINING OR FACING TUBS, SHOWERS AND OTHER WET SURFACES WHERE THE BOTTOM EDGE OF THE GLAZING IS LESS THAN 60-INCHES MEASURED VERTICALLY ABOVE ANY STANDING OR WALKING SURFACES, INCLUDING SHOWER DOORS AND SURROUNDS.
   F) GLAZING ADJACENT TO STAIRS AND RAMPS.
- AZING TERIAL N N INSIDE WOOD NO NO ARAGE DOOR OUTSIDE WOOD NO ARAGE DOOR OUTSIDE WOOD NO NO OUTSIDE WOOD NO INSIDE WOOD NO INSIDE WOOD NO OUTSIDE WOOD NO NO OUTSIDE WOOD NO INSIDE WOOD NO NO INSIDE WOOD NO NO OUTSIDE WOOD NO NO

# Symbols

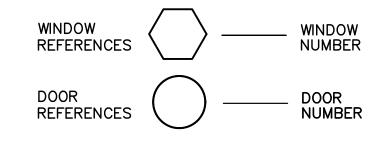


# Abbreviations

	CLAUDIO ORTIZ DESIGN GROUP, INC P.O. BOX 3775 Carmel, CA 93921 OFFICE: 831.626.4146 CLAUDIO@CODGINC.COM WWW.CODGINC.COM
	MUTANTIA DAVING A DAVIET DAVIE
REVISIONS:	
PROJECT: Breidenbach residence 7650 Mills RD	MONTEREY, CA. 93940 BLOCK: N/A LOT: 88 APN: 259-111-028-000 <b>PROJECT NO.</b>
<b>ISSUE:</b> 04-12-2023	<b>DRAWN BY:</b> D.Santana
-	ROPOSED)

WINI SCH (PRC

SCALE: 1/4" = 1'

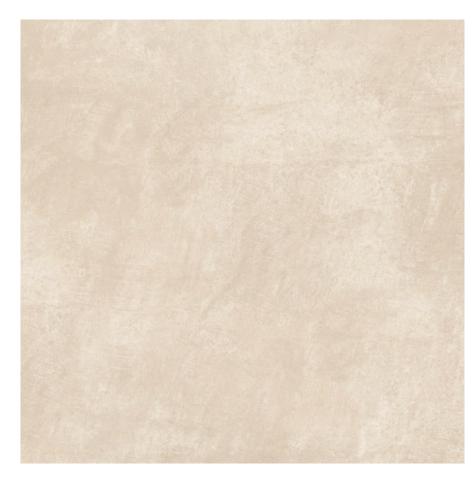


PLASTER SIDING COLOR: BAGE (AGED WHITE)



COLOR:

MODEL: -

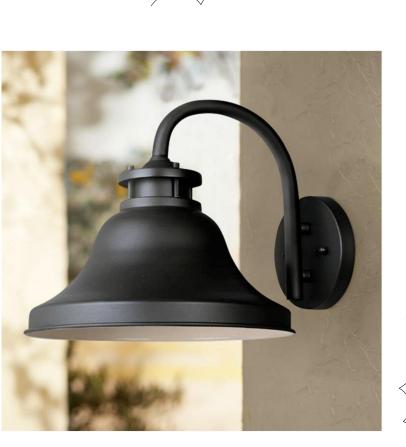

# FIXTURE A

T24 COMPLIANT: YES COLOR: WATTS: LUMENS: BULB TYPE: DIMENSIONS: DARK SKY:

MANUFACTURE: DESIGNERS FOUNTAINS BRONZE SEE LIGHT BULB SEE LIGHT BULB STANDARD 110.25"H X 11"W X 13.5" YES

 $\checkmark$ 

# SLATE ROOF MANUFACTURE: SHELTON ROOFING CO. TBD




# COLOR EXTERIOR

MANUFACTURE: COLOR: LOCATION: LOCATOR NUMBER: 261-C4

SHERWIN-WILLIAMS EXTERIOR

AGED WHITE / SW 7575

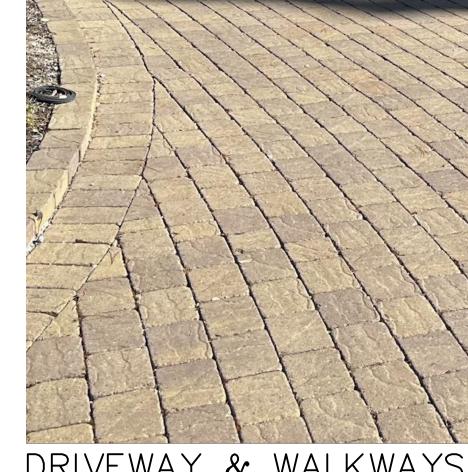

DRIVEWAY & WALKWAYS MANUFACTURE: FLAGSTONE PAVERS.COM MATERIAL: NATURAL STONE COLOR: NATURAL





BULB WATTS: LUMENS: BULB TYPE:

MANUFACTURE: FEIT ELECTRIC 40 WATTS EQUIVALENT TO 60 150 B11 LED SOCKET


# WINDOW FRAME COLOR EXTERIOR PER WINDOW MANUFACTURE (TO MATCH MAIN STRUCTURE) COLOR:



WINDOW MANUFACTURE:

TBD

C BOX 3775 Carmel, CA 93921 OFFICE: 831,626,4146 CLAUDIO@CODGINC.COM WWW.CODGINC.COM
THE DRAWINGS , APRANCEMENTS, ANNOTATIONS AND GRAPHICAL REESENTATIONS ON THIS DOCUMENT ARE THE PROPERTY OF CLAUDIO ORTIZ DESIGNA GROUP ING. AND/OR CLAUDIO ORTIZ WO RETAINS OWNERSHIP AND THIS DOCUMENT IS ANNOTATIONS IN THE INTELLECTUAL AND PHYSICL PROPERTY OF CLAUDIO ORTIZ AND PHYSICL PROPERTY OF CLAUDIO ORTIZ COPYRIGHT 2016 CLAUDIO ORTIZ COPYRIGHT 2016 CLAUDIO ORTIZ COPYRIGHT 2016 CLAUDIO ORTIZ
<b>REVISIONS:</b> 03-11-2024 <u>▲</u>
PROJECT: BREIDENBACH RESIDENCE 7650 MILLS RD MONTEREY, CA. 93940 BLOCK: N/A LOT: 88 APN: 259-111-028-000 PROJECT NO. 22-02
<b>ISSUE:</b> 04-12-2023 DRAWN BY: D.Santana
SCALE: 1/4" = 1'

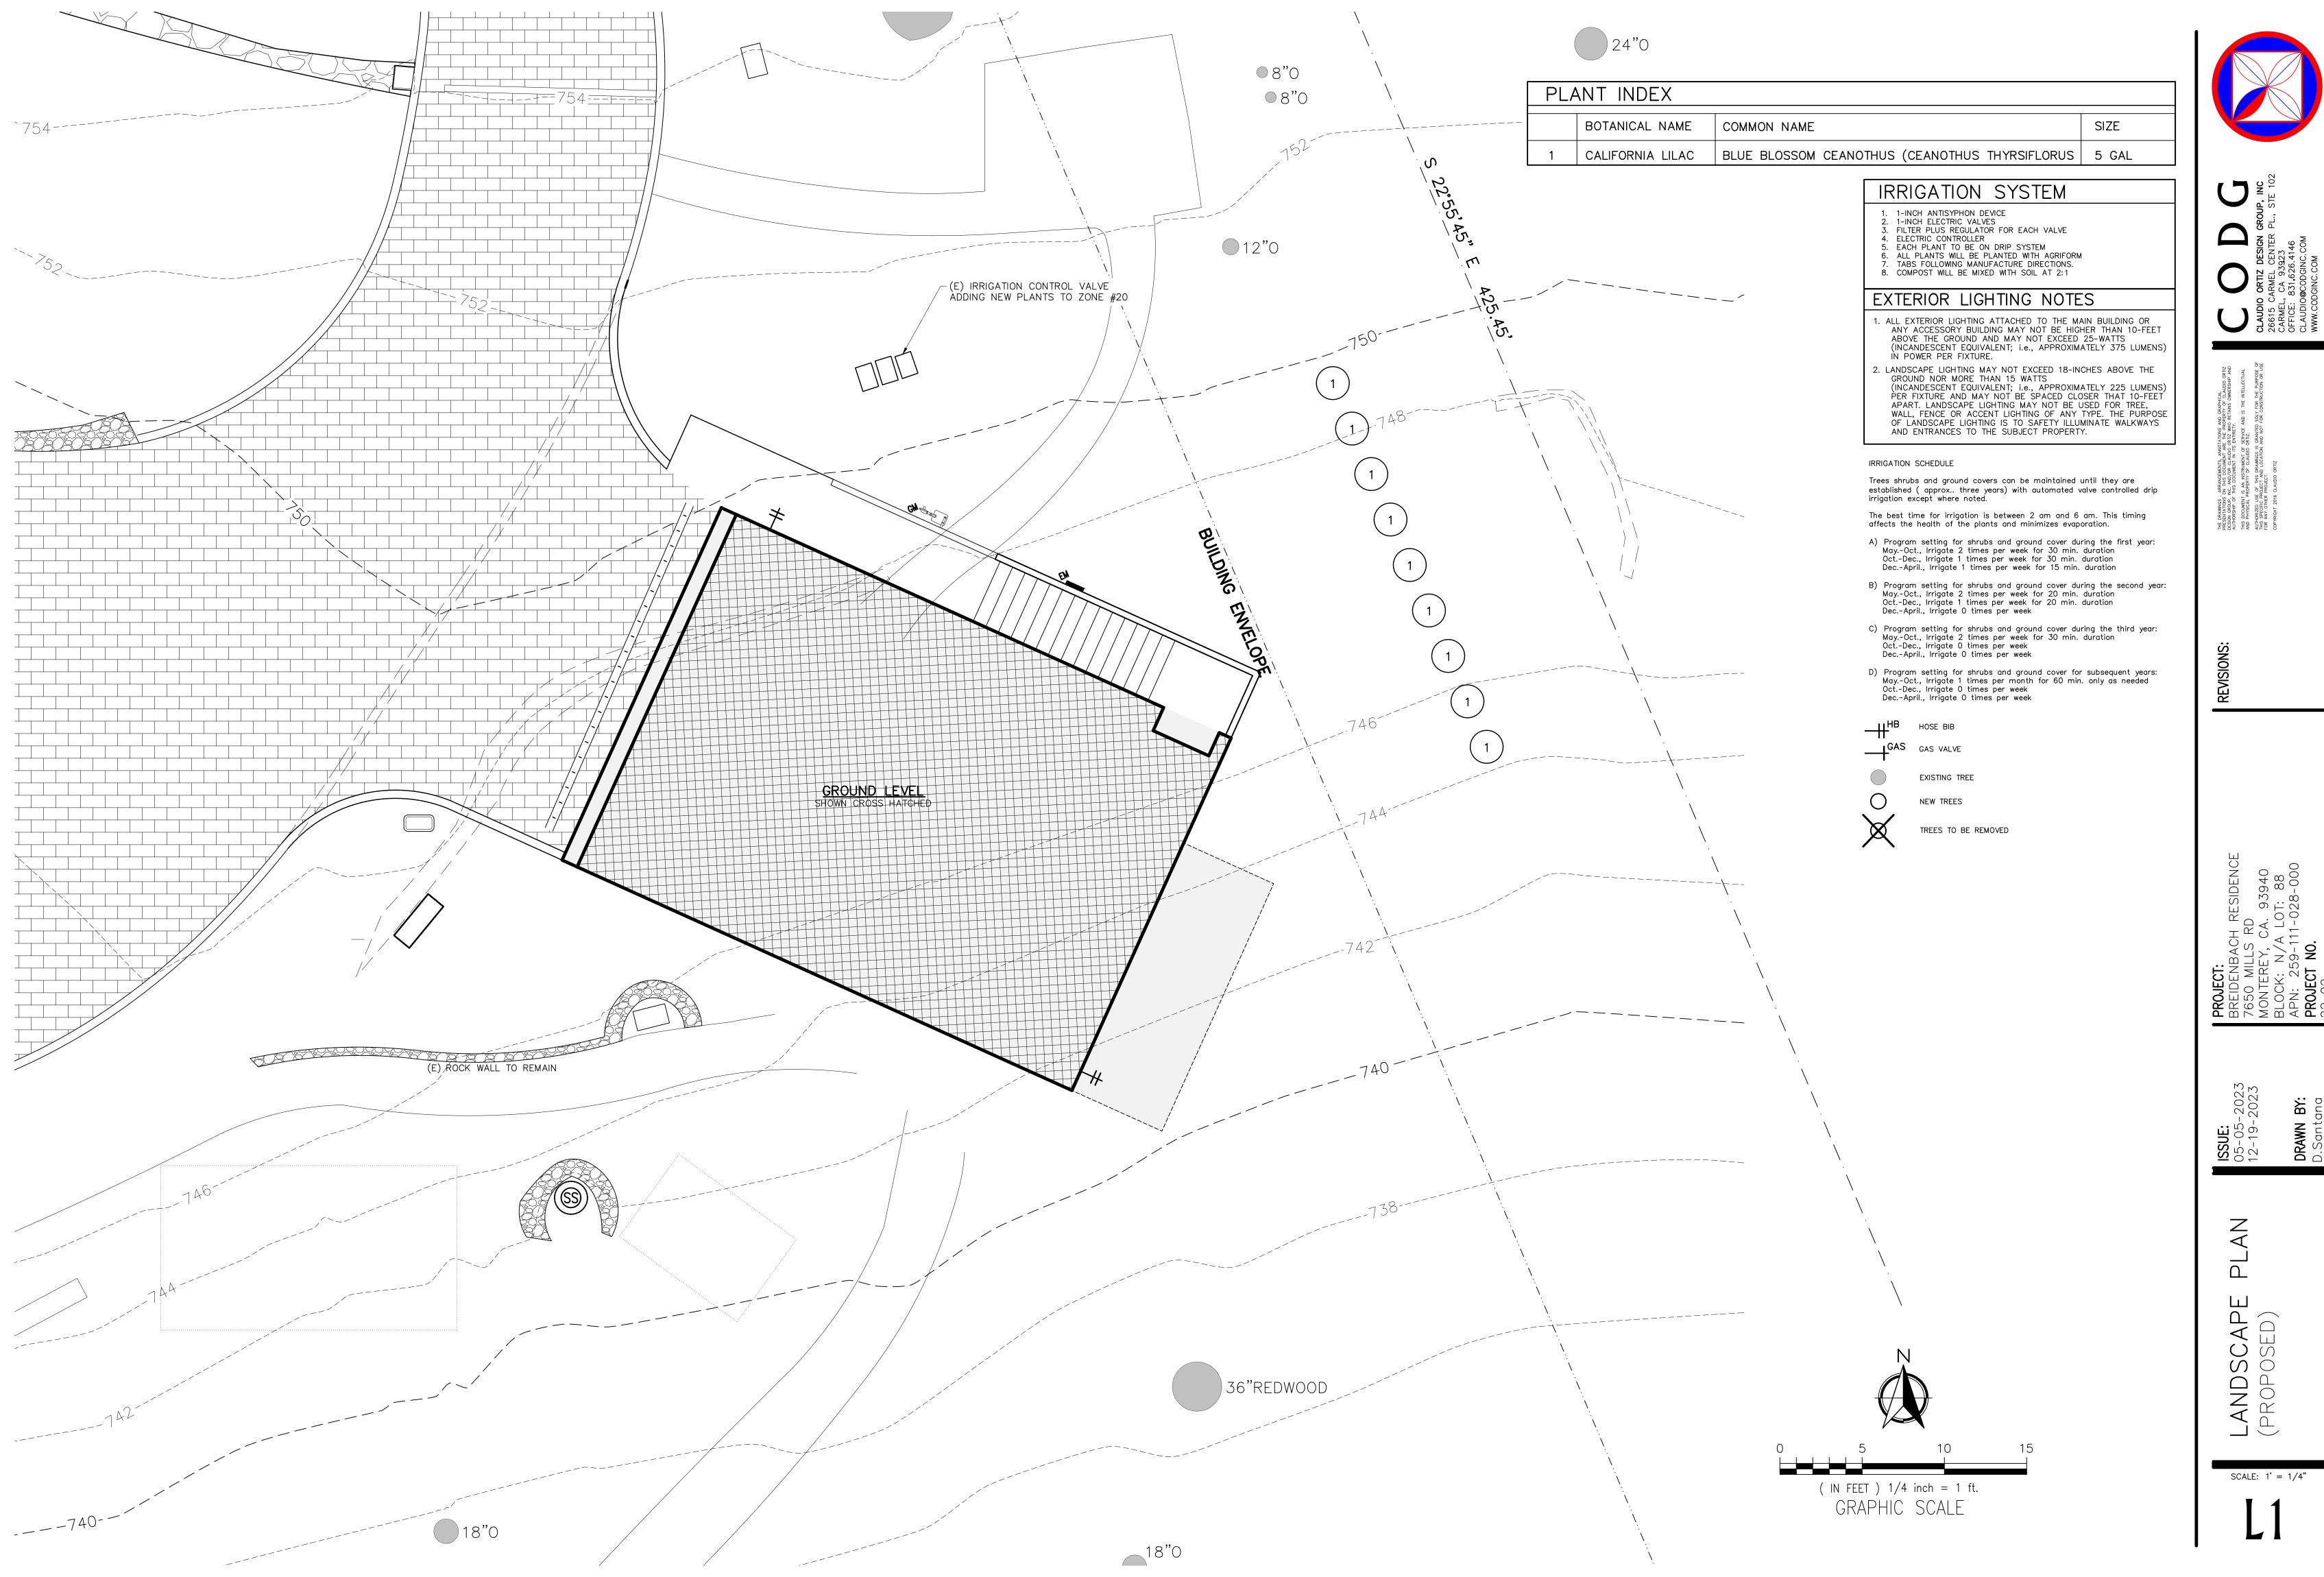

# **GENERAL NOTES**

1. ALL WORK SHALL BE COMPLETED IN ACCORDANCE WITH THESE PLANS AND ACCOMPANYING SPECIFICATIONS. IN ADDITION ALL WORK SHALL ALSO CONFORM WITH THE FOLLOWING: - LATEST REVISION OF THE COUNTY OF MONTEREY COUNTY OF DESIGN STANDARDS AND SPECIFICATIONS - THE LATEST REVISION OF THE STATE OF CALIFORNIA DEPARTMENT OF TRANSPORTATION STANDARDS AND

SPECIFICATIONS (STATE SPECIFICATIONS) - THE PROJECT GEOTECHNICAL INVESTIGATION (DATED JANUARY 27, 2006, BY SOIL SURVEY INC.)

- THE 2022 EDITIONS OF THE CALIFORNIA BUILDING CODE (CBC), CALIFORNIA PLUMBING CODE (CPC), CALIFORNIA MECHANICAL CODE (CMC), CALIFORNIA ENERGY CODE (CEnC), CALIFORNIA ELECTRICAL CODE (CEC), CALIFORNIA FIRES CODE (CFC).

2. THE CONTRACTOR SHALL FAMILIARIZE HIMSELF WITH THE PLANS. DETAILS. AND SPECIFICATIONS AND SITE CONDITIONS PRIOR TO THE START OF CONSTRUCTION. IN THE EVENT THAT THE CONTRACTOR FINDS ANY DISCREPANCIES. OMISSIONS. OR DEFICIENCIES IN THE PLANS. THE CONTRACTOR SHALL NOTIFY THE DESIGN ENGINEER.

3. IT IS THE CONTRACTORS RESPONSIBILITY TO SECURE ALL REQUIRED PERMITS PRIOR TO THE START OF CONSTRUCTION. GRADING PERMITS EXPIRE 180 DAYS FROM ISSUANCE DATE.

4. THE LOCATIONS AND SIZE OF UNDERGROUND UTILITIES AND OR OTHER STRUCTURES SHOWN HEREON WERE OBTAINED FROM A FIELD SURVEY (BY OTHERS) AND OR FROM RECORD INFORMATION. NEITHER THE ENGINEER NOR THE OWNER MAKES ANY REPRESENTATION TO THE ACCURACY OF SIZE AND OR LOCATION OF ANY OF THE UTILITIES OR STRUCTURES SHOWN ON THESE PLANS NOR FOR THE EXISTENCE OF ANY OTHER BURIED OBJECTS OR UTILITIES WHICH MAY BE ENCOUNTERED THAT ARE NOT SHOWN ON THIS PLAN. IT IS THE CONTRACTOR'S RESPONSIBILITY TO FIELD VERIFY THE SIZE AND LOCATION OF EXISTING UNDERGROUND UTILITIES, SURFACE IMPROVEMENTS, AND OTHER STRUCTURES AND TAKE ALL NECESSARY PRECAUTIONS TO PROTECT THEM FROM DAMAGE DURING CONSTRUCTION.

5. THE CONTRACTOR SHALL BE RESPONSIBLE FOR CONTACTING APPROPRIATE UTILITY COMPANIES AND REQUESTING VERIFICATION OF SERVICE POINTS, FIELD VERIFICATION OF LOCATION, SIZE, DEPTH, ETC. FOR ALL THEIR FACILITIES AND TO COORDINATE WORK SCHEDULES.

6. THE CONTRACTOR SHALL NOTIFY UNDERGROUND SERVICE ALERT AT (800) 227-2600 AT LEAST 48 HOURS PRIOR TO EXCAVATION TO VERIFY THE LOCATION OF EXISTING UNDERGROUND UTILITIES AND MAINTAIN A CURRENT DIG ALERT/811 TICKET THROUGHOUT THE PROJECT.

7. CONTRACTOR IS RESPONSIBLE FOR COMPLIANCE WITH ANY CURRENTLY APPLICABLE SAFETY LAW OF ANY JURISDICTIONAL BODY. FOR INFORMATION REGARDING THIS PROVISION. THE CONTRACTOR IS DIRECTED TO CONTACT THE STATE OF CALIFORNIA, DIVISION OF OCCUPATIONAL SAFETY AND HEALTH. THE CONTRACTOR SHALL BE RESPONSIBLE FOR ALL BARRICADES, SAFETY DEVICES, AND THE CONTROL OF TRAFFIC WITHIN THE CONSTRUCTION AREA. FOR ALL TRENCH EXCAVATION FIVE (5) FEET OR MORE IN DEPTH, THE CONTRACTOR SHALL OBTAIN A PERMIT FROM THE DIVISION OF OCCUPATIONAL SAFETY AND HEALTH PRIOR TO BEGINNING ANY EXCAVATION. A COPY OF THIS PERMIT SHALL BE AVAILABLE AT THE CONSTRUCTION SITE AT ALL TIMES.

8. EXISTING CURB, GUTTER, SIDEWALK, SURVEY MONUMENTS, AND OTHER IMPROVEMENTS WITHIN PROJECT SITE THAT ARE DAMAGED OR DISPLACED AS A RESULT OF THE CONTRACTOR'S ACTIVITIES SHALL BE REPLACED BY THE CONTRACTOR.

9. THE CONTRACTOR SHALL ASSUME SOLE AND COMPLETE RESPONSIBILITY FOR THE JOB SITE CONDITIONS AND SAFETY OF ALL PERSONS AND PROPERTY DURING THE COURSE OF CONSTRUCTION OF THE PROJECT. THE CONTRACTOR AGREES TO HOLD HARMLESS. INDEMNIFY AND DEFEND THE OWNER. THE ENGINEER. AND ALL DESIGN CONSULTANTS FROM ANY AND ALL LIABILITY, CLAIMS, LOSSES OR DAMAGES ARISING FROM THE PERFORMANCE OF THE WORK DESCRIBED HEREIN EXCEPT THOSE ARISING FROM THE SOLE NEGLIGENCE OF ANY OF THE PREVIOUSLY MENTIONED PEOPLE OR ENTITIES. THIS REQUIREMENT SHALL BE MADE TO APPLY CONTINUOUSLY AND NOT BE LIMITED TO NORMAL WORKING HOURS.

10. CONTRACTOR SHALL BE RESPONSIBLE FOR REMOVAL, OFF-HAUL AND DISPOSE OF ALL ITEMS TO BE REMOVED INCLUDING BUT NOT LIMITED TO: ASPHALT. CONCRETE STRIPING. ANY AND ALL OTHER DEBRIS FROM THE SITE. EXCESS FROM TRENCHING AND PAVEMENT CONSTRUCTION, TREES AND ROOT-BALLS FENCING AND SPOILS FROM EXCAVATION AT THE CONTRACTOR'S EXPENSE.

11. IF ARCHAEOLOGICAL RESOURCES OR HUMAN REMAINS ARE DISCOVERED DURING CONSTRUCTION, WORK SHALL BE HALTED WITHIN 150 FEET OF THE FIND UNTIL IT CAN BE EVALUATED BY A QUALIFIED PROFESSIONAL ARCHAEOLOGIST. IF THE FIND IS DETERMINED TO BE SIGNIFICANT, APPROPRIATE MITIGATION MEASURES SHALL BE FORMULATED AND IMPLEMENTED.

12. ALL REVISIONS TO THESE PLANS MUST BE APPROVED BY THE ENGINEER AND BUILDING OFFICIALS AS WELL AS THE OWNER PRIOR TO THEIR CONSTRUCTION AND SHALL BE ACCURATELY SHOWN ON RECORD DRAWINGS PRIOR TO THE ACCEPTANCE OF THE WORK AS COMPLETE. ANY CHANGES TO OR DEVIATIONS FROM THE PLANS MADE WITHOUT AUTHORIZATION SHALL BE AT THE CONTRACTOR'S SOLE RISK AND SHALL ABSOLVE THE ENGINEER OF ANY AND ALL RESPONSIBILITY ASSOCIATED WITH THE CHANGE OR DEVIATION.

13. THE CONTRACTOR SHALL TAKE ALL NECESSARY MEASURES TO KEEP THE SITE AND ADJACENT AREAS FREE FROM DIRT AND DEBRIS. SHOULD ANY DIRT OR DEBRIS BE DEPOSITED IN THE PUBLIC RIGHT-OF-WAY, THE CONTRACTOR SHALL REMOVE IT IMMEDIATELY.

14. THE CONTRACTOR SHALL TAKE ALL NECESSARY MEASURES TO PREVENT AIRBORNE DUST FROM BECOMING A NUISANCE. DUST CONTROL MEASURES TO BE IMPLEMENTED INCLUDE BUT ARE NOT LIMITED TO THE FOLLOWING:

A) PROVIDE EQUIPMENT AND MANPOWER REQUIRED FOR WATERING ALL EXPOSED OR DISTURBED EARTH B) COVER STOCKPILES OF DEBRIS, SOIL, OR OTHER MATERIALS WHICH MAY CONTRIBUTE TO AIRBORNE DUST. C) KEEP CONSTRUCTION AREAS AND ADJACENT STREET FREE OF MUD AND DUST.

D) LANDSCAPE, SEED, OR COVER PORTIONS OF THE SITE AS SOON AS CONSTRUCTION IS COMPLETE.

15. A COPY OF ALL FIELD REPORTS/COMPACTIONS TESTS AND FINAL GRADING REPORT SHALL BE SUBMITTED TO THE COUNTY AT SCHEDULED INSPECTIONS.

16. PAD ELEVATION/S SHALL BE CERTIFIED TO 0.1 FEET, PRIOR TO DIGGING ANY FOOTINGS OR SCHEDULING ANY INSPECTIONS.

17. CONTRACTOR SHALL POTHOLE AND VERIFY THAT A MINIMUM OF ONE FOOT OF VERTICAL SEPARATION CAN BE ACHIEVED AT ALL NEW SEWER CROSSINGS AND NOTIFY THE ENGINEER IF ANY EXISTING UTILITIES APPEAR TO BE IN CONFLICT.

# STORM DRAIN

1. ALL STORM DRAIN PIPING 6"-24" SHALL BE HIGH DENSITY POLYETHYLENE TYPE-S WITH INTEGRAL BELL & SPIGOT JOINTS (ADS-N12 OR EQUAL) OR PVC (SDR 35). INSTALLATION SHALL BE PER MANUFACTURERS SPECIFICATIONS OR AS SHOWN ON PLANS.

2. STORM DRAIN MANHOLES SHALL BE CONSTRUCTED TO THE COUNTY STANDARD SPECIFICATIONS AND STANDARD DETAILS.

3. ALL STORM DRAIN PIPE SHALL BE RIGID. NO FLEX PIPE.

# SANITARY SEWER

1. SANITARY SEWER MANHOLES SHALL BE CONSTRUCTED TO THE COUNTY STANDARD SPECIFICATIONS AND STANDARD DETAILS.

2. SANITARY SEWER PIPE SHALL BE POLYVINYL CHLORIDE (PVC) PLASTIC GRAVITY SEWER PIPE WITH INTEGRAL WALL BELL AND SPIGOT JOINTS. ALL SOLID WALL PIPE, FITTINGS AND COUPLINGS IN 4" THROUGH 15" INCH DIAMETERS SHALL CONFORM TO ASTM 03033 AND ASTM 03034, SDR 35 MINIMUM.

3. PIPE SHALL BE INSTALLED IN COMPLIANCE WITH THE STANDARD SPECIFICATIONS AND THE MANUFACTURERS RECOMMENDED TRENCH CONSTRUCTION PRACTICE FOR SEMI-RIGID PVC SEWER PIPE AND AS DIRECTED BY THE COUNTY.

4. SEWER SERVICE LATERALS SHALL BE CONSTRUCTED TO THE COUNTY STANDARD SPECIFICATIONS AND STANDARD

5. ALL SEWER SERVICES SHALL BE MARKED WITH A "S" ON TOP OF CURB.

DETAILS.

6. SANITARY SEWER CLEAN OUTS SHALL BE INSTALLED AT INTERVALS NOT TO EXCEED 100 FEET.

# GRADING & DRAINAGE

1. CONTRACTOR SHALL NOTIFY THE COUNTY 48 HOURS BEFORE STARTING ANY GRADING OPERATIONS.

2. ALL GRADING SHALL CONFORM TO THE COUNTY GRADING ORDINANCE AND THE PROJECT SOILS REPORT.

3. THE SOILS ENGINEER SHALL BE NOTIFIED AT LEAST THREE (3) DAYS IN ADVANCE OF COMMENCING WORK, INCLUDING SITE STRIPPING AND GRADING OPERATIONS. THIS WORK SHALL BE OBSERVED AND TESTED BY THE SOILS ENGINEER.

4. IT IS THE CONTRACTOR'S RESPONSIBILITY TO SECURE THE REQUIRED PERMITS PRIOR TO THE COMMENCEMENT OF GRADING. RIGHT-OF-ENTRY, PERMISSION TO GRADE, AND ENCROACHMENT PERMIT(S) MAY BE REQUIRED PRIOR TO GRADING.

5. IT IS THE CONTRACTORS RESPONSIBILITY TO PREPARE THE GROUND SURFACE TO RECEIVE THE FILLS TO THE SATISFACTION OF THE SOIL ENGINEER AND TO PLACE, SPREAD, MIX, WATER, AND COMPACT THE FILL IN ACCORDANCE WITH THE RECOMMENDATIONS OF THE PROJECT GEOTECHNICAL INVESTIGATION. THE CONTRACTOR SHALL ALSO REMOVE ALL MATERIAL CONSIDERED UNSATISFACTORY BY THE SOILS ENGINEER.

6. WHERE UNSTABLE OR UNSUITABLE MATERIALS ARE ENCOUNTERED DURING SUB-GRADE PREPARATION, THE AREA IN QUESTION SHALL BE OVER EXCAVATED AND BACKFILLED WITH SELECT MATERIAL AS DIRECTED IN THE FIELD BY THE SOIL ENGINEER.

WRITING BY THE SOILS ENGINEER.

8. ALL CUT SLOPES SHALL BE ROUNDED TO MEET EXISTING GRADES AND BLEND WITH SURROUNDING TOPOGRAPHY. ALL GRADED SLOPES SHALL BE PLANTED WITH SUITABLE GROUND COVER.

9. TREE REMOVAL SHALL INCLUDE REMOVAL OF TRUNKS, STUMPS, AND ROO-TBALLS. THE REMAINING CAVITY SHALL BE CLEARED OF ALL ROOTS LARGER THAN 1/2" TO A DEPTH OF NOT LESS THAN 18" AND BACKFILLED WITH SUITABLE MATERIAL THEN COMPACTED TO CONFORM WITH THE EXISTING GROUND.

11. EARTHWORK QUANTITIES: CUT = **0** CY FILL = **67** CY NET = 67 CY FILL

EARTHWORK QUANTITIES ARE ESTIMATES ONLY. IT IS THE RESPONSIBILITY OF THE CONTRACTOR TO VERIFY THE ACTUAL EARTHWORK QUANTITIES. NO ALLOWANCE HAS BEEN MADE TO ACCOUNT FOR QUANTITIES FROM TRENCHING FOR FOUNDATION, FOOTINGS, PIERS AND/OR UTILITIES TRENCHES.

12. ALL SURFACE DRAINAGE SHALL MAINTAIN 2% SLOPE MINIMUM.

13. PERVIOUS SURFACES IMMEDIATELY ADJACENT TO THE FOUNDATION SHALL BE SLOPED AWAY FROM THE BUILDING AT A SLOPE OF NOT LESS THAN 5% FOR A MINIMUM DISTANCE OF 10 FEET MEASURED PERPENDICULAR TO THE FACE OF THE WALL. IF PHYSICAL OBSTRUCTIONS OR LOT LINES PROHIBIT 10 FEET OF HORIZONTAL DISTANCE, A 5% SLOPE SHALL BE PROVIDED TO AN APPROVED ALTERNATIVE METHOD OF DIVERTING WATER AWAY FROM THE FOUNDATION. SWALES USED FOR THIS PURPOSE SHALL BE SLOPED A MINIMUM OF 2% WHERE LOCATED WITHIN 10 FEET OF THE BUILDING FOUNDATION. IMPERVIOUS SURFACES WITHIN 10 FEET OF THE BUILDING FOUNDATION SHALL BE SLOPED A MINIMUM OF 2% AWAY FROM THE BUILDING.

14. INVERTS OF ALL STORM DRAIN LINES CONNECTING RETAINING WALL SUB-DRAINS AND FOUNDATION SUB-DRAINS SHALL BE FIELD VERIFIED AFTER FOOTINGS ARE PLACED.

15. BUILDINGS CONSTRUCTED ACROSS CUT/FILL LINE SHALL HAVE COMPACTION TESTS TAKEN ALONG THE CUT AREA AS WELL AS THE FILL AREA. TESTS SHALL MEET 90% OF THE RELATIVE COMPACTION PER ASTM D1557.

16. ALL STORM DRAIN MAINS SHALL HAVE A MINIMUM OF 12" COVER.

17. DURING WINTER OPERATIONS (BETWEEN OCTOBER 1ST AND APRIL 30TH) THE FOLLOWING MEASURES MUST BE TAKEN:

- GRADING/EROSION ORD.2806-16.12.090)

18. VEGETATION REMOVAL. ACTUAL GRADING SHALL BEGIN WITHIN 30 DAYS OF VEGETATION REMOVAL.

19. NO VEGETATION REMOVAL OR GRADING WILL BE ALLOWED WHICH WILL RESULT IN SILTATION OF WATER COURSES OR UNCONTROLLABLE EROSION.

20. PREPARATION OF THE GROUND FOR FILL. THE GROUND SURFACE SHALL BE PREPARED TO RECEIVE FILL BY REMOVING VEGETATION, NON-COMPLYING FILL, TOPSOIL AND OTHER UNSUITABLE MATERIALS SCARIFYING TO PROVIDE A BOND WITH THE NEW FILL, AS DETERMINED BY THE SOIL ENGINEER.

21. FILL MATERIAL PERMITTED. NO ORGANIC MATERIAL SHALL BE PERMITTED IN FILL EXCEPT AS TOPSOIL USED FOR SURFACE PLANT GROWTH ONLY AND WHICH DOES NOT EXCEED 4 INCHES IN DEPTH.

DRIVEWAY.

# **UNDERGROUND UTILITIES**

1. CONTRACTOR SHALL EXPOSE AND VERIFY LOCATION AND ELEVATION OF EXISTING UTILITIES, INCLUDING STORM DRAINS, SANITARY SEWERS AND WATER LINES, BEFORE ORDERING MATERIALS AND/OR CONSTRUCTING NEW FACILITIES. 2. ALL EXISTING MANHOLES AND UTILITY BOXES WITHIN THE PROJECT AREA ARE TO BE SET FLUSH WITH FINISHED

GRADE, UNLESS OTHERWISE NOTED.

3. ALL TRENCHES AND EXCAVATIONS SHALL BE CONSTRUCTED IN STRICT COMPLIANCE WITH THE APPLICABLE SECTIONS OF CALIFORNIA AND FEDERAL O.S.H.A. REQUIREMENTS AND OTHER APPLICABLE SAFETY ORDINANCES. CONTRACTOR SHALL BEAR FULL RESPONSIBILITY FOR TRENCH SHORING DESIGN AND INSTALLATION.

4. PIPE MATERIALS AND INSTALLATION PROCEDURE SHALL BE IN ACCORDANCE WITH APPLICABLE SECTIONS OF THE STANDARD SPECIFICATIONS AND THE MANUFACTURER'S RECOMMENDATIONS.

5. SHOULD ANY WATER SYSTEM MAINS OR SERVICES BE DAMAGED BY THE CONTRACTOR, THE WATER SYSTEM SHALL BE REPAIRED IN ACCORDANCE WITH THE STANDARD SPECIFICATIONS OF THE COUNTY.

A LOCAL BENCHMARK FOR THIS PROJECT IS A 60D NAIL SET NEAR BOCCE BALL COURT AS SHOWN HEREON, HAVING AN ELEVATION OF 746.40 BASED UPON AN ASSUMED DATUM. (SEE SHEET C3)

7. MAXIMUM CUT AND FILL SLOPE SHALL BE 2 HORIZONTAL TO 1 VERTICAL UNLESS OTHERWISE DIRECTED IN

10. CONTRACTOR SHALL USE CAUTION WHEN GRADING AROUND AND/OR OVER EXISTING UNDERGROUND UTILITIES.

A. DISTURBED SURFACES NOT INVOLVED IN IMMEDIATE OPERATIONS MUST BE PROTECTED BY MULCHING AND OR OTHER EFFECTIVE MEANS OF SOIL PROTECTION.

B. ALL ROADS AND DRIVEWAYS SHALL HAVE DRAINAGE FACILITIES SUFFICIENT TO PREVENT EROSION ON OR ADJACENT TO THE ROADWAY OR ON DOWNHILL PROPERTIES.

C. RUN-OFF FROM THE SITE SHALL BE DETAINED OR FILTERED BY BERMS, VEGETATED FILTER STRIPS, AND OR CATCH BASINS TO PREVENT THE ESCAPE OF SEDIMENT FROM THE SITE.

D. DRAINAGE CONTROL MEASURES SHALL BE MAINTAINED AND IN PLACE AT THE END OF EACH DAY AND CONTINUOUSLY THROUGH THE LIFE OF THE PROJECT DURING WINTER OPERATIONS (MONTEREY COUNTY

22. THE ULTIMATE PURPOSE OF GRADING IS FOR THE CONSTRUCTION OF A SINGLE FAMILY RESIDENCE AND

# BENCHMARK

# TREE PROTECTION NOTES

THE FOLLOWING ACTIVITIES ARE PROHIBITED WITHIN THE LIMITS OF THE CRITICAL ROOT ZONE OF ANY PROTECTED TREE. 1. MATERIAL STORAGE: NO STORAGE OR PLACEMENT OF MATERIALS INTENDED FOR USE IN CONSTRUCTION OR WASTE MATERIALS ACCUMULATED DUE TO EXCAVATION OR DEMOLITION SHALL BE PLACED WITHIN THE LIMITS OF THE CRITICAL ROOT ZONE OF ANY PROTECTED TREE.

2. EQUIPMENT CLEANING/LIQUID DISPOSAL: NO EQUIPMENT SHALL BE CLEANED OR OTHER LIQUIDS, INCLUDING, WITHOUT LIMITATION, PAINT, OIL, SOLVENTS, ASPHALT, CONCRETE, MORTAR OR SIMILAR MATERIALS DEPOSITED OR ALLOWED TO FLOW ONTO THE GROUND. ALL CONTAMINANTS SHALL BE DISPOSED OF IN ACCORDANCE WITH THE CASAQ CONSTRUCTION BEST MANAGEMENT PRACTICES, SEE EROSION CONTROL PLAN SHEET C6.

3. TREE ATTACHMENTS: NO SIGNS, WIRES OR OTHER ATTACHMENTS, OTHER THAN THOSE OF A PROTECTIVE NATURE, SHALL BE ATTACHED TO ANY PROTECTED TREE.

4. VEHICULAR TRAFFIC: NO VEHICULAR AND/OR CONSTRUCTION EQUIPMENT TRAFFIC OR PARKING SHALL TAKE PLACE WITHIN THE CRITICAL ROOT ZONE OF ANY PROTECTED TREE OTHER THAN ON EXISTING STREET PAVEMENT. THIS RESTRICTION DOES NOT APPLY TO SINGLE INCIDENT ACCESS WITHIN THE CRITICAL ROOT ZONE FOR PURPOSES OF ESTABLISHING THE BUILDING PAD AND ASSOCIATED LOT GRADING, VEHICULAR TRAFFIC NECESSARY FOR ROUTINE UTILITY MAINTENANCE, EMERGENCY RESTORATION OF UTILITY SERVICE, OR ROUTINE MOWING OPERATIONS.

5. NO HEAVY EQUIPMENT, INCLUDING BUT NOT LIMITED TO TRUCKS, TRACTORS, TRAILERS, BULLDOZERS, BOBCAT TRACTORS, TRENCHERS, COMPRESSORS, AND HOISTS, SHALL BE ALLOWED INSIDE THE DRIP-LINE OF ANY PROTECTED TREE ON ANY CONSTRUCTION SITE WITHOUT PRIOR WRITTEN APPROVAL FROM THE COUNTY FORESTER.

6. ROOT PRUNING: ALL ROOTS TWO INCHES OR LARGER IN DIAMETER WHICH ARE EXPOSED AS A RESULT OF TRENCHING OR OTHER EXCAVATION SHALL BE CUT OFF SQUARE WITH A SHARP MEDIUM TOOTH SAW AND COVERED WITH PRUNING COMPOUND WITHIN TWO HOURS OF INITIAL EXPOSURE.


THE FOLLOWING PROCEDURES SHALL BE FOLLOWED ON ALL TYPES OF CONSTRUCTION PROJECTS (INCLUDING RESIDENTIAL, COMMERCIAL, AND MUNICIPAL / PUBLIC DOMAIN PROJECTS).

1. PROTECTIVE FENCING: PRIOR TO THE ISSUANCE OF ANY BUILDING OR EARTH DISTURBANCE PERMIT, OR COMMENCING CONSTRUCTION. THE OWNER. CONTRACTOR OR SUBCONTRACTOR SHALL REQUIRE TREE PROTECTION INSPECTION AND APPROVAL BY THE COUNTY FORESTER, FOR EACH PROTECTED TREE ON A CONSTRUCTION SITE, A PROTECTIVE FENCING WHICH ENCIRCLE THE OUTER LIMITS OF THE CRITICAL ROOT ZONE OF THE TREE TO PROTECT IT FROM CONSTRUCTION ACTIVITY.

2. ALL PROTECTIVE FENCING SHALL BE IN PLACE PRIOR TO COMMENCEMENT OF ANY SITE WORK AND REMAIN IN PLACE UNTIL ALL EXTERIOR CONSTRUCTION ACTIVITY AT THE SITE HAS BEEN COMPLETED.

3. PROTECTIVE FENCING SHALL BE AT LEAST FOUR (4) FEET HIGH, CLEARLY VISIBLE, AND BE CLEARLY VISIBLE TO WORKERS ON THE SITE.


4. THE USE OF ORANGE VINYL CONSTRUCTION FENCING OR OTHER SIMILAR FENCING IS GENERALLY PERMITTED ONLY IF THERE IS NO CONSTRUCTION OR VEHICULAR ACTIVITY WITHIN TEN (10) FEET OF THE FENCE. IF CONSTRUCTION ACTIVITY OR VEHICULAR TRAFFIC IS EXPECTED WITHIN TEN (10) FEET OF THE FENCE, THE CONTRACTOR SHALL ALSO CONSULT WITH THE COUNTY FORESTER ON BARK PROTECTION REQUIREMENTS.

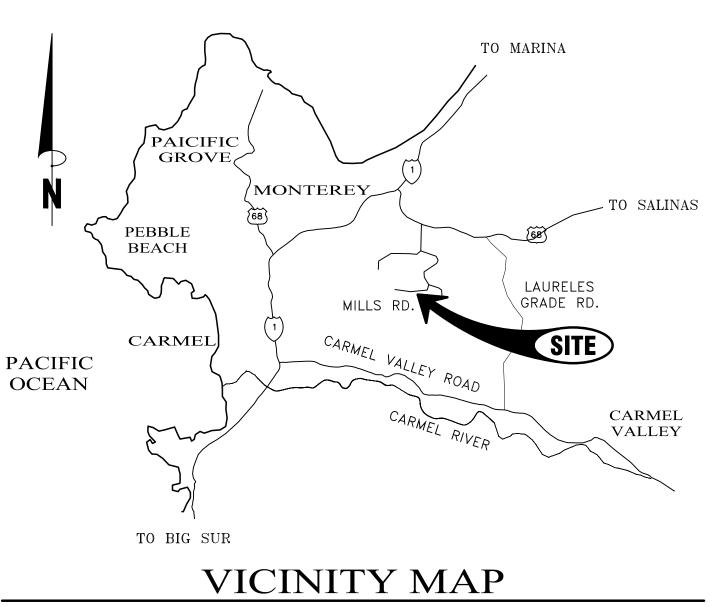



# **GEOTECHNICAL INSPECTION SC**


WHEN THE INSPECTION IS TO BE COMPLETED:	WHO WILL CONDUCT THE INSPECTION:
1) PRIOR TO BACKFILLING 2) DURING BACKFILL PLACEMENT - OPENING	GEOTECHNICAL INSPECTOR
1) PRIOR TO EXCAVATION FOOTINGS OR PLACEMENT OF SLAB-ON-GRADE MATERIALS	GEOTECHNICAL INSPECTOR
1) PRIOR TO CONCRETE PLACEMENT	GEOTECHNICAL INSPECTOR
1) PRIOR TO REINFORCEMENT PLACEMENT	GEOTECHNICAL INSPECTOR
1) DURING BACKFILL PLACEMENT - ONGOING	GEOTECHNICAL INSPECTOR
1) DURING FILL PLACEMENT 2) SUBGRADE, PRIOR TO BASE ROCK PLACEMENT 3) BASEROCK PRIOR TO AC, CONCRETE OR PAVEMENT	GEOTECHNICAL INSPECTOR
1) AFTER PIPE PLACEMENT, PRIOR TO TO BACKFILL PLACEMENT 2) DURING BACKFILL PLACEMENT - ONGOING	GEOTECHNICAL INSPECTOR
1) AFTER TANK PLACEMENT 2) DURING BACKFILL PLACEMENT - ONGOING	GEOTECHNICAL INSPECTOR
TABLE PROVIDED FOR REFERENCE ONLY. C3 ENGI	NEERING, INC. IS NOT RESPONSIBLE FOR


EXISTING		PROPOSED			
	- BOUNDARY LINE				
	- EASEMENT (ESMT) - CENTERLINE (CL)				
SD		SD			
	ROOF DRAIN LATERAL				
SS	- SANITARY SEWER MAIN	SS			
W	- WATER MAIN	w			
$- \leftarrow \leftarrow \leftarrow \leftarrow \leftarrow \leftarrow$	- DRAINAGE FLOW LINE SAWCUT	$ \longrightarrow \longrightarrow \longrightarrow \longrightarrow \longrightarrow \longrightarrow \longrightarrow \longrightarrow$			
GB GB GB GB GB-		GB GB GB GB GB GB GB GB			
	ACCESSIBLE PATH OF TRAVEL	*************	<u>କ</u>	\$ \$ \$ \$ \$ \$ \$ \$ \$ \$ \$ \$ \$ \$ \$ \$ \$ \$ \$	ଏ ଏ ଏ
- <u> </u>		170			
—		169 X X X			4 D
× 405.4		• FG		ant	0.0 19,0
	DROP INLET (DI)	171.13		Land Development Management	Ľ.
	CURB INLET (CI)			/elo Mer	, Monterey, CA Fax (831) 647
	AREA DRAIN (AD)	AD		De age	Place, Suite C, Montere ) 647-1192   Fax (831)
SDMH ( SSMH (		● SDMH ● SSMH		Land Developr Management	Ξâ Lâ
25IMIT (	FIRE DEPARTMENT CONNECTION (FDC)			<u> </u>	Suite 1192
FH (	FIRE HYDRANT (FH)	₩ FH		Engineering Stormwater	ce, S 17-1
Č	POST INDICATOR VALVE (PIV)	€IN 6IN		inee	126 Bonifacio Place, Phone: [831] 647-
WM 🗈				Sto	ifacio 183,
⊲ ∨W	WATER VALVE (WV) CHECK VALVE				Boni one:
				U	126 Ph
C	CLEANOUT (CO)	•			·
C1 COVER & GENERAL NOTES C2 OVERALL SITE PLAN C3 GRADING & DRAINAGE PLAN C4 UTILITY PLAN		EX	PROFESSION	No. 61	EXP. 06/30/25 CIVIL
C2 OVERALL SITE PLAN C3 GRADING & DRAINAGE PLAN			-   III	No. 61	EXP. 06/30/25
C2 OVERALL SITE PLAN C3 GRADING & DRAINAGE PLAN C4 UTILITY PLAN C5 SECTIONS & DETAILS C6 EROSION CONTROL PLAN	S S	BIT BEFORE BEFOR	PROFES	SIDENCE No. 61	
C2 OVERALL SITE PLAN C3 GRADING & DRAINAGE PLAN C4 UTILITY PLAN C5 SECTIONS & DETAILS C6 EROSION CONTROL PLAN C7 EROSION CONTROL DETAILS	S S	BIT BEFORE	AL NOTES	DENCE No. 61	
C2 OVERALL SITE PLAN C3 GRADING & DRAINAGE PLAN C4 UTILITY PLAN C5 SECTIONS & DETAILS C6 EROSION CONTROL PLAN C7 EROSION CONTROL DETAILS C7 EROSION CONTROL DETAILS	SPACE	BIT BEFORE BEFOR	ER SHEET RAL NOTES	3ACH RESIDENCE 2000	
C2 OVERALL SITE PLAN C3 GRADING & DRAINAGE PLAN C4 UTILITY PLAN C5 SECTIONS & DETAILS C6 EROSION CONTROL PLAN C7 EROSION CONTROL DETAILS EDULE SPECTION ITEM:	INSPECTION		ER SHEET RAL NOTES	ACH RESIDENCE	TEED Wills Boad Montorov CA
C2 OVERALL SITE PLAN C3 GRADING & DRAINAGE PLAN C4 UTILITY PLAN C5 SECTIONS & DETAILS C6 EROSION CONTROL PLAN C7 EROSION CONTROL DETAILS EDULE SPECTION ITEM: INSPECT & TEST KEYWAY /SUE /OVEREXCAVATON:	INSPECTION		COVER SHEET GENERAL NOTES	VBACH RESIDENCE 259-111-028-000	Docation: 7650 Wills Docad Montaria CA
C2 OVERALL SITE PLAN C3 GRADING & DRAINAGE PLAN C4 UTILITY PLAN C5 SECTIONS & DETAILS C6 EROSION CONTROL PLAN C7 EROSION CONTROL DETAILS EDULE SPECTION ITEM: INSPECT & TEST KEYWAY /SUE	INSPECTION E:		ER SHEET RAL NOTES	EIDENBACH RESIDENCE	Docation: 7650 Mills Boad Montered CA
C2 OVERALL SITE PLAN C3 GRADING & DRAINAGE PLAN C4 UTILITY PLAN C5 SECTIONS & DETAILS C6 EROSION CONTROL PLAN C7 EROSION CONTROL DETAILS C7 EROSION CONTROL DETAILS EDULE SPECTION ITEM: INSPECT & TEST KEYWAY /SUE /OVEREXCAVATON: INSPECT & TEST PAD SUBGRAD	INSPECTION E: ALLATION:		COVER SHEET GENERAL NOTES	VBACH RESIDENCE 259-111-028-000	Docation: 7650 Mills Boad Montered CA
C2 OVERALL SITE PLAN C3 GRADING & DRAINAGE PLAN C4 UTILITY PLAN C5 SECTIONS & DETAILS C6 EROSION CONTROL PLAN C7 EROSION CONTROL DETAILS EDULE SPECTION ITEM: INSPECT & TEST KEYWAY /SUE /OVEREXCAVATON: INSPECT & TEST KEYWAY /SUE INSPECT & TEST PAD SUBGRAD INSPECT SLAB-ON-GRADE INST INSPECT FOUNDATION AND/OR WALL FOOTING EXCAVATIONS:	INSPECTION E: ALLATION: RETAINING		COVER SHEET GENERAL NOTES	EIDENBACH RESIDENCE	Brotact Location: 7650 Mills Boad Montarev CA
C2 OVERALL SITE PLAN C3 GRADING & DRAINAGE PLAN C4 UTILITY PLAN C5 SECTIONS & DETAILS C6 EROSION CONTROL PLAN C7 EROSION CONTROL DETAILS EDULE SPECTION ITEM: INSPECT & TEST KEYWAY /SUE /OVEREXCAVATON: INSPECT & TEST PAD SUBGRAD INSPECT SLAB-ON-GRADE INST INSPECT FOUNDATION AND/OR	INSPECTION E: ALLATION: RETAINING WALL BACKFILL:		COVER SHEET GENERAL NOTES	BREIDENBACH RESIDENCE APN# 259-111-028-000	Docation: 7650 Mills Docad Montorov CA
C2 OVERALL SITE PLAN C3 GRADING & DRAINAGE PLAN C4 UTILITY PLAN C5 SECTIONS & DETAILS C6 EROSION CONTROL PLAN C7 EROSION CONTROL DETAILS C7 EROSION CONTROL DETAILS SPECTION ITEM: INSPECT & TEST KEYWAY /SUE /OVEREXCAVATON: INSPECT & TEST KEYWAY /SUE /OVEREXCAVATON: INSPECT SLAB-ON-GRADE INST INSPECT FOUNDATION AND/OR WALL FOOTING EXCAVATIONS: INSPECT AND TEST RETAINING Y	INSPECTION E: ALLATION: RETAINING WALL BACKFILL: TILL, SUBGRADE		COVER SHEET & GENERAL NOTES	BREIDENBACH RESIDENCE APN# 259-111-028-000	A Noticed All A A A A A A A A A A A A A A A A A

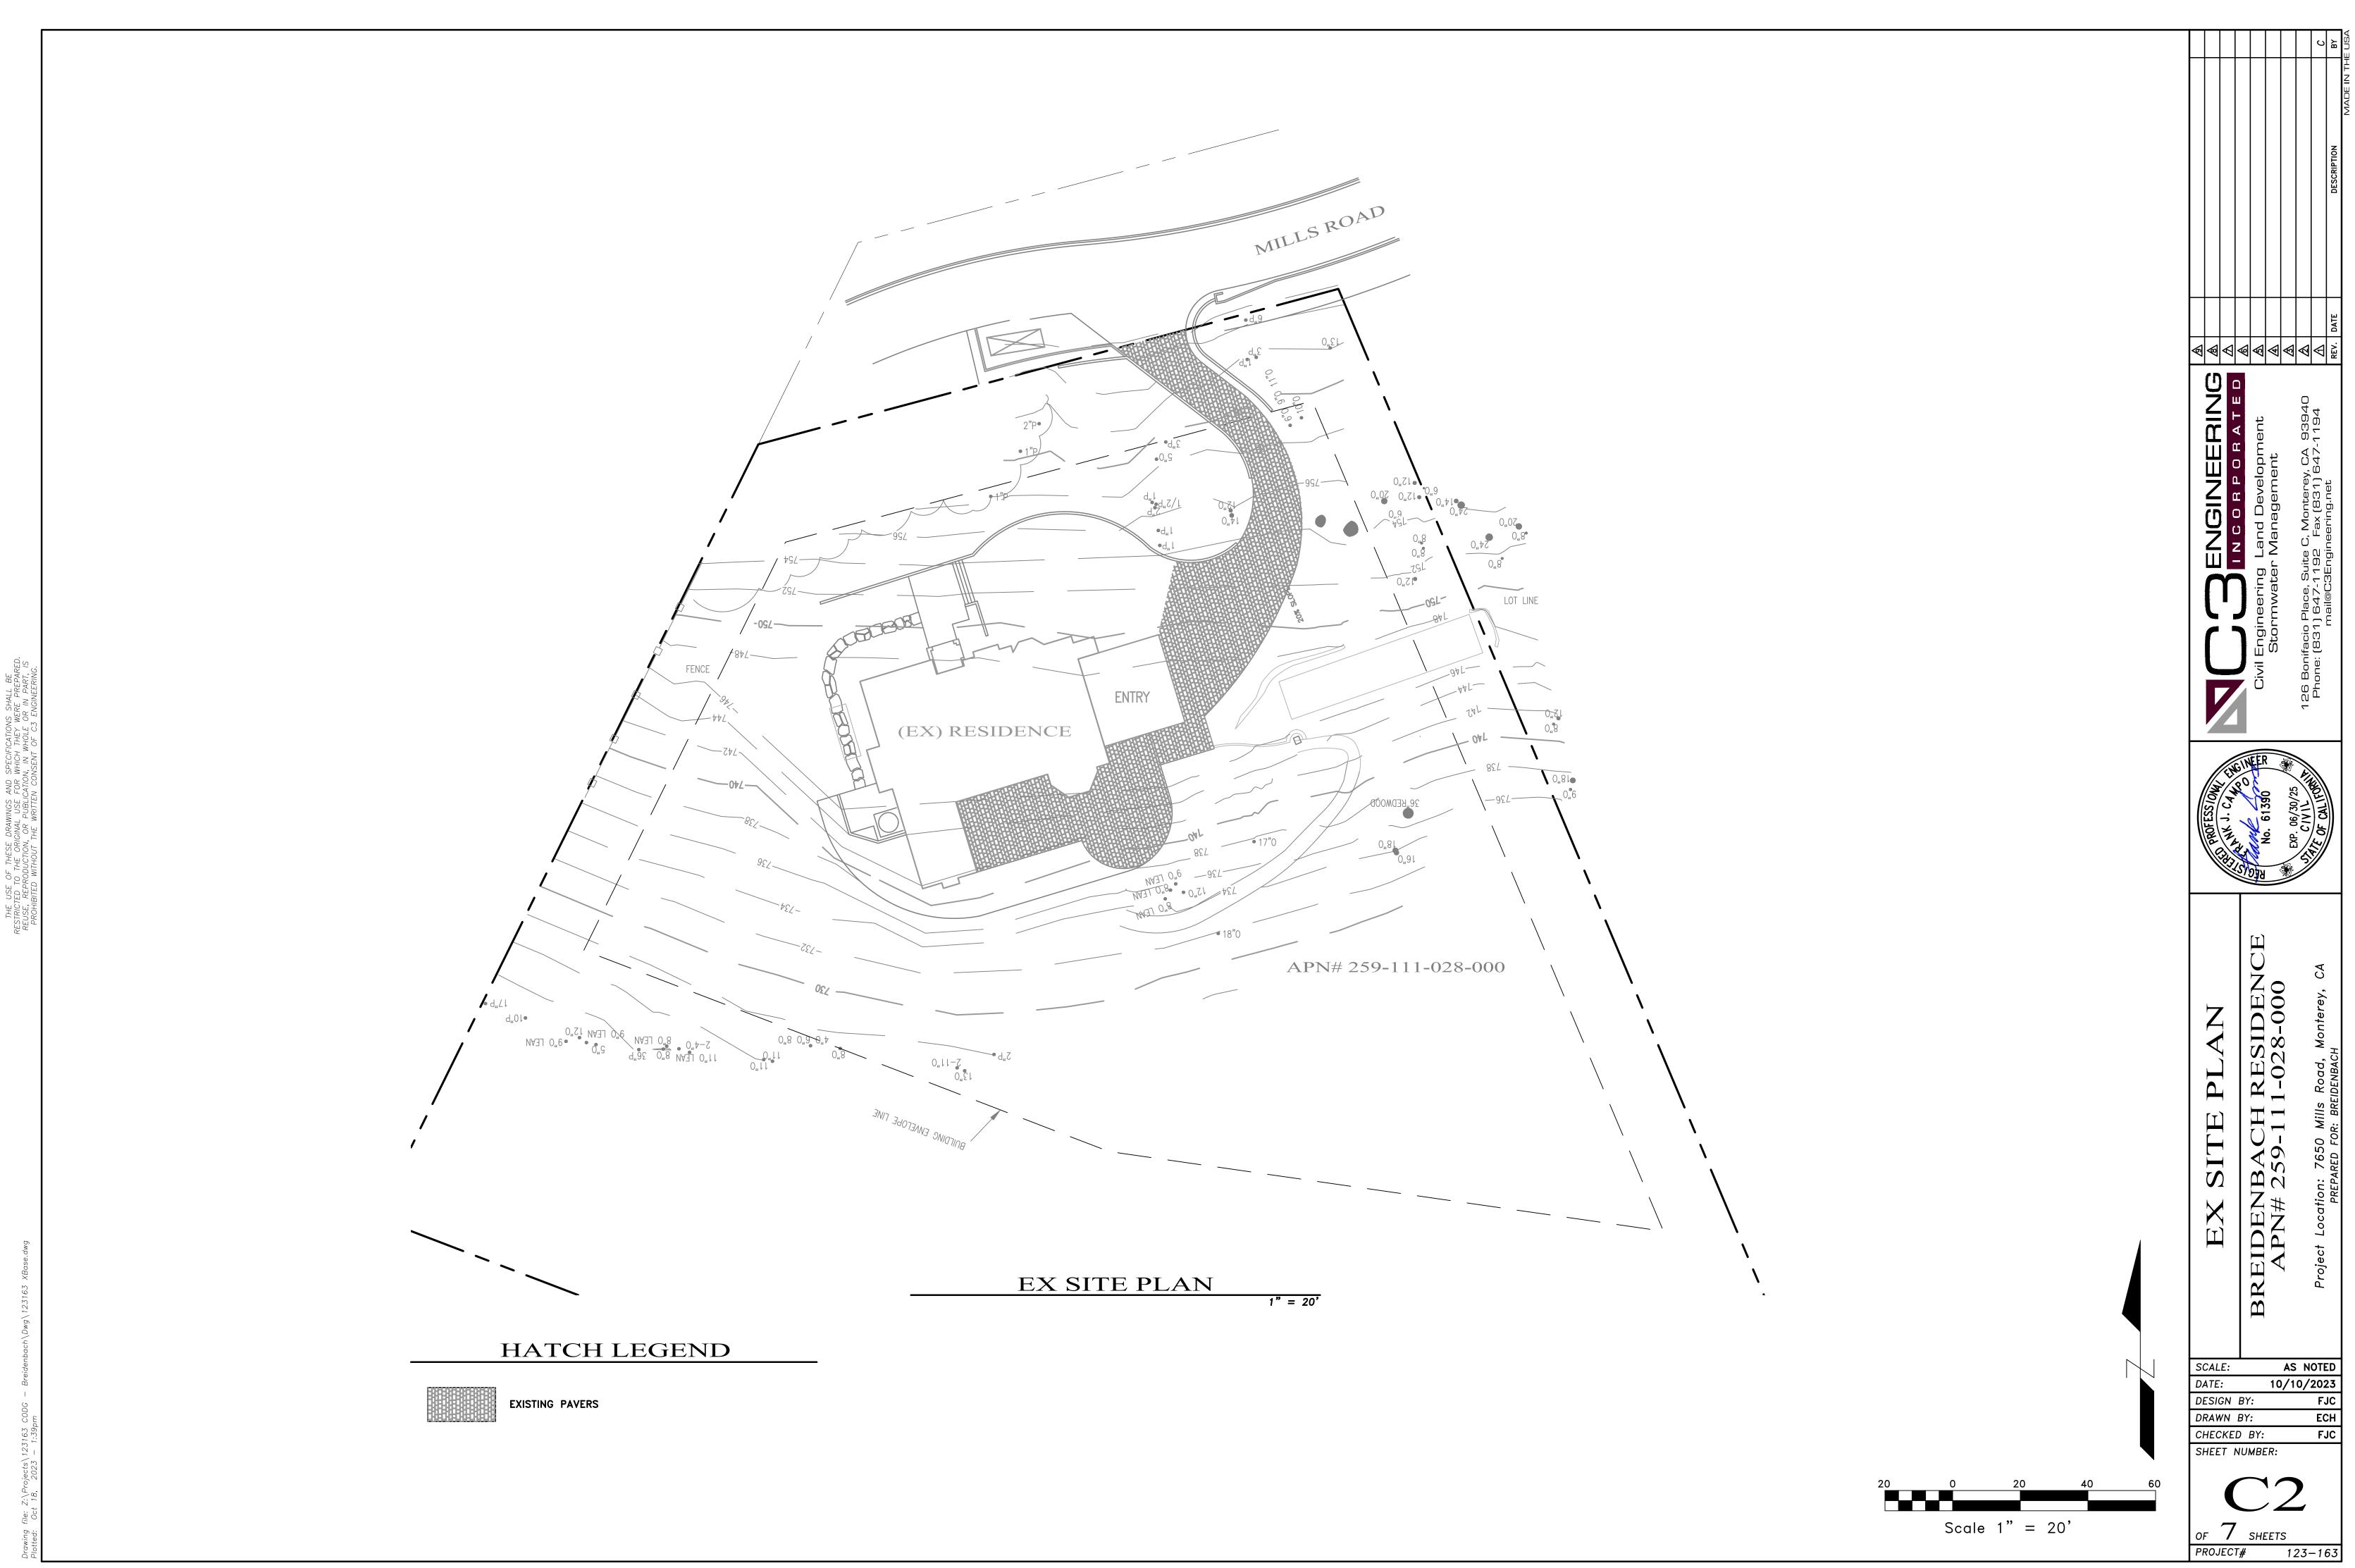

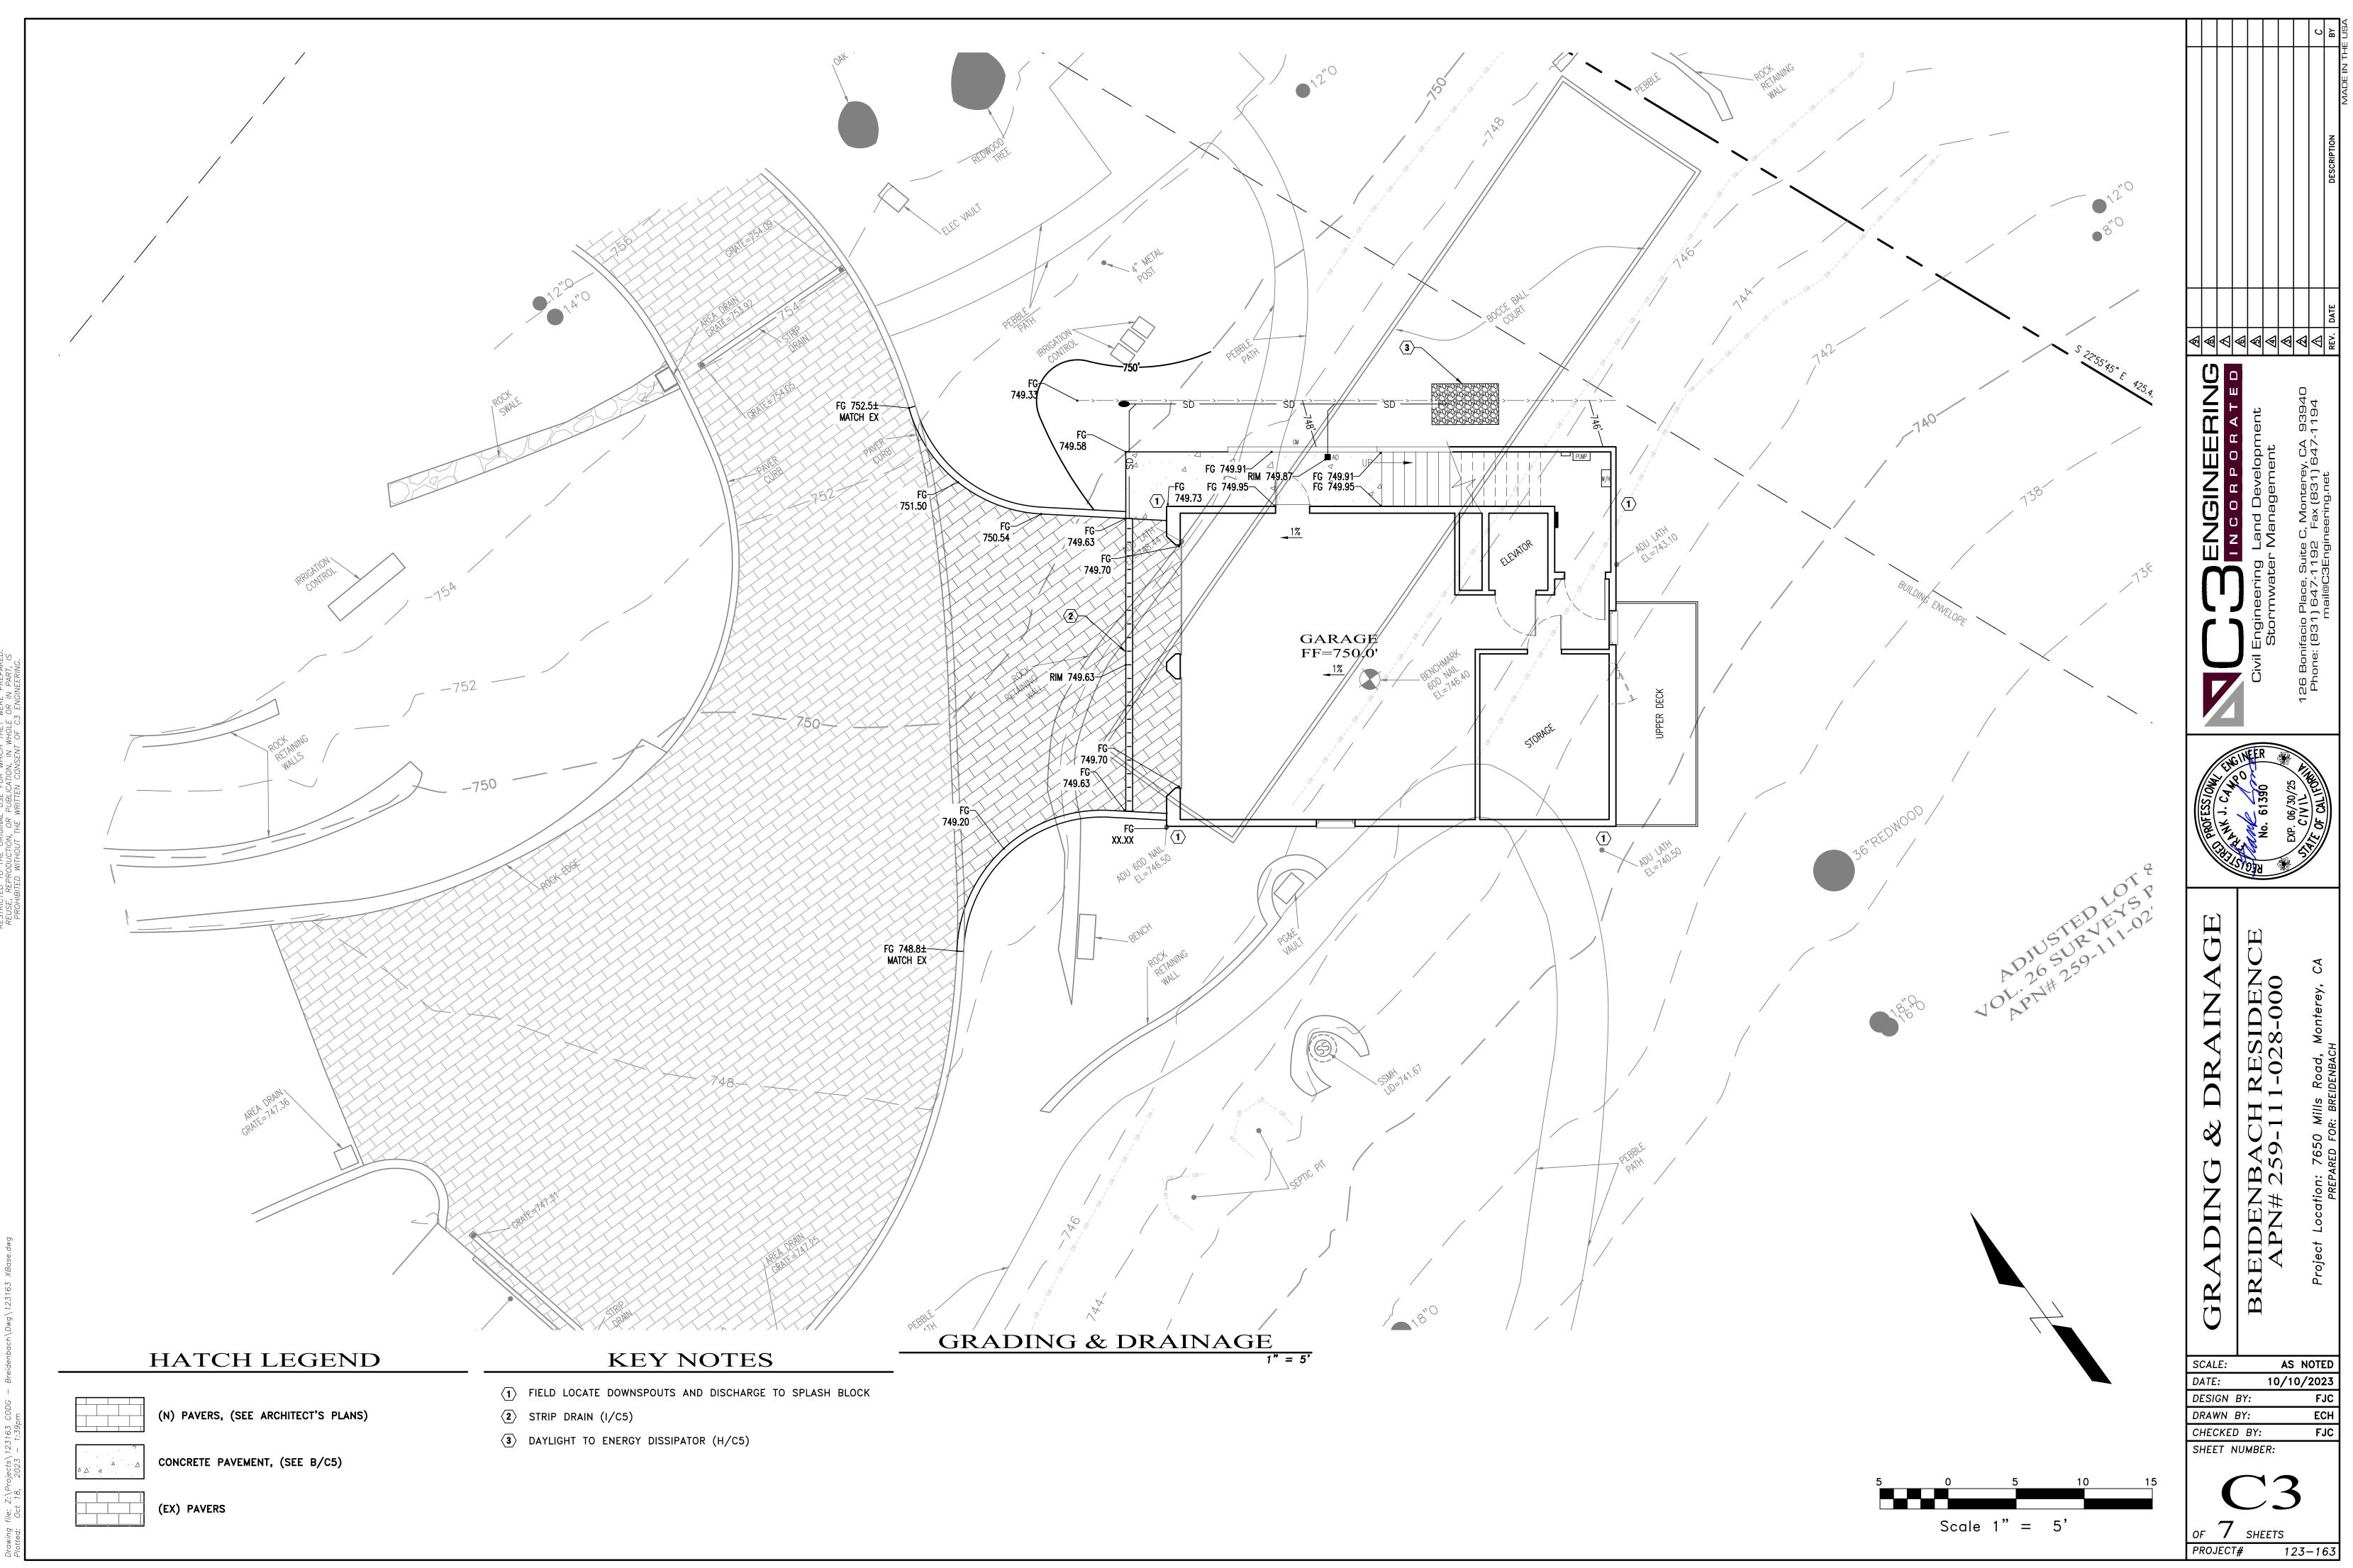

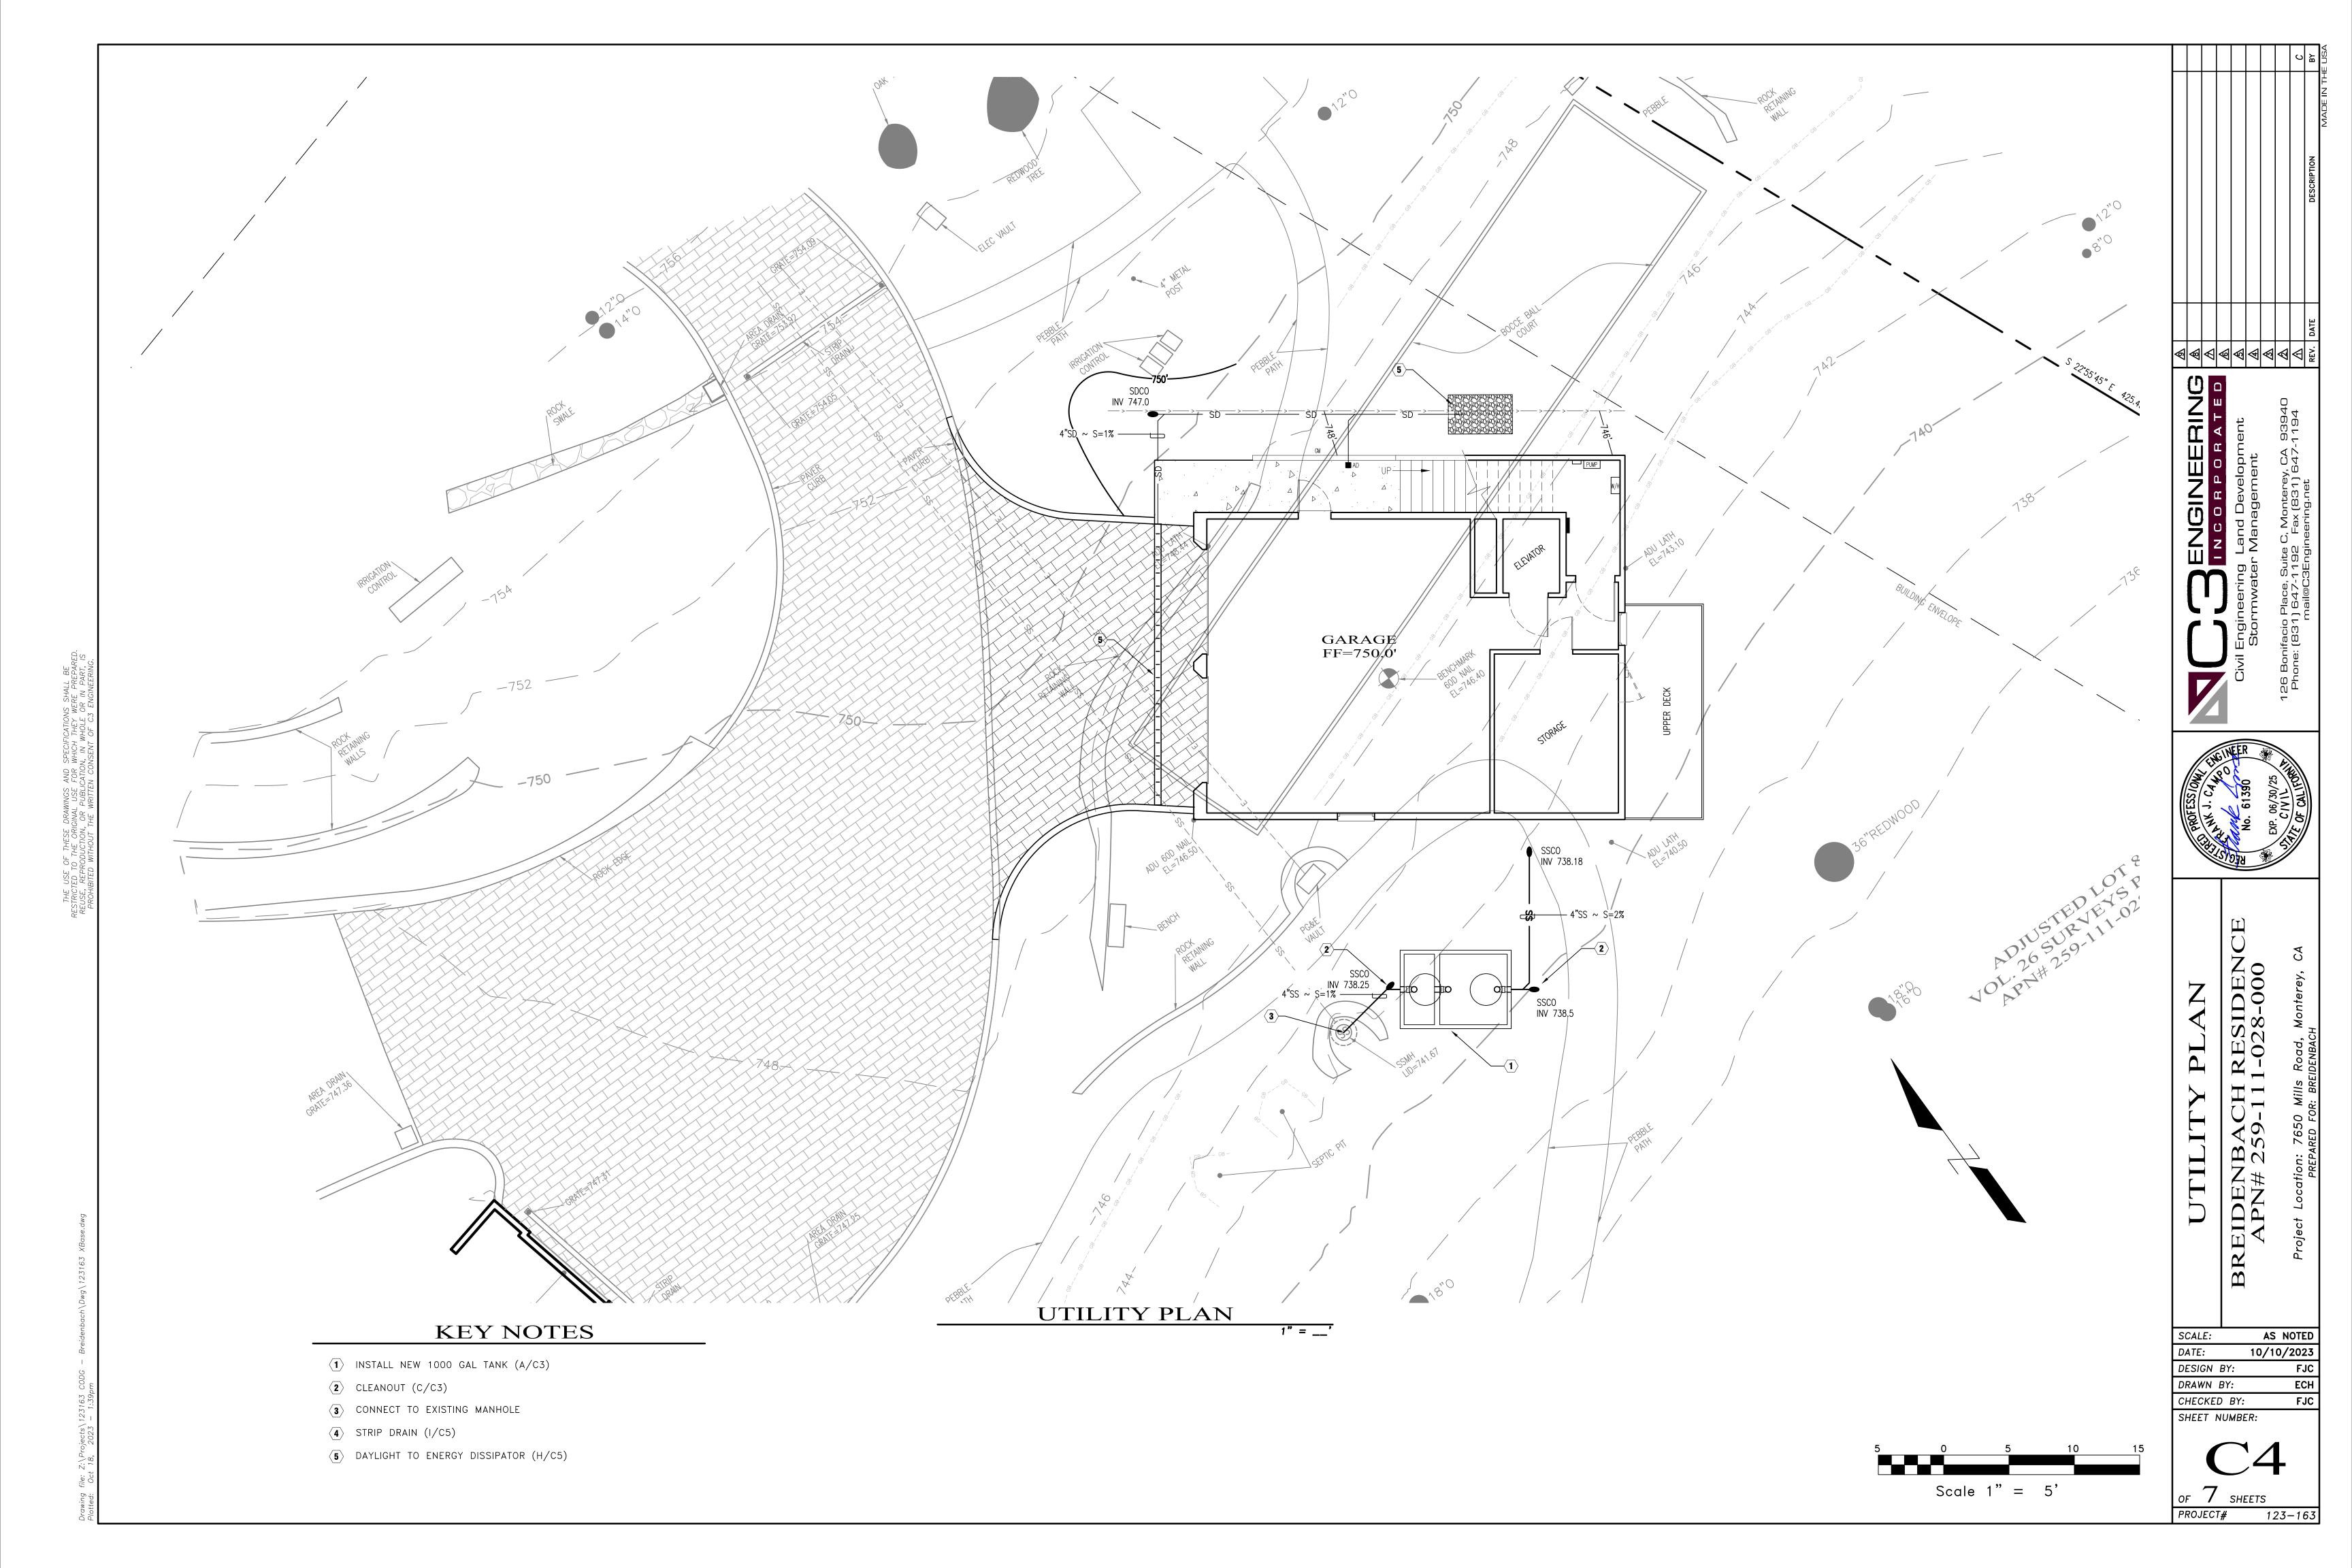

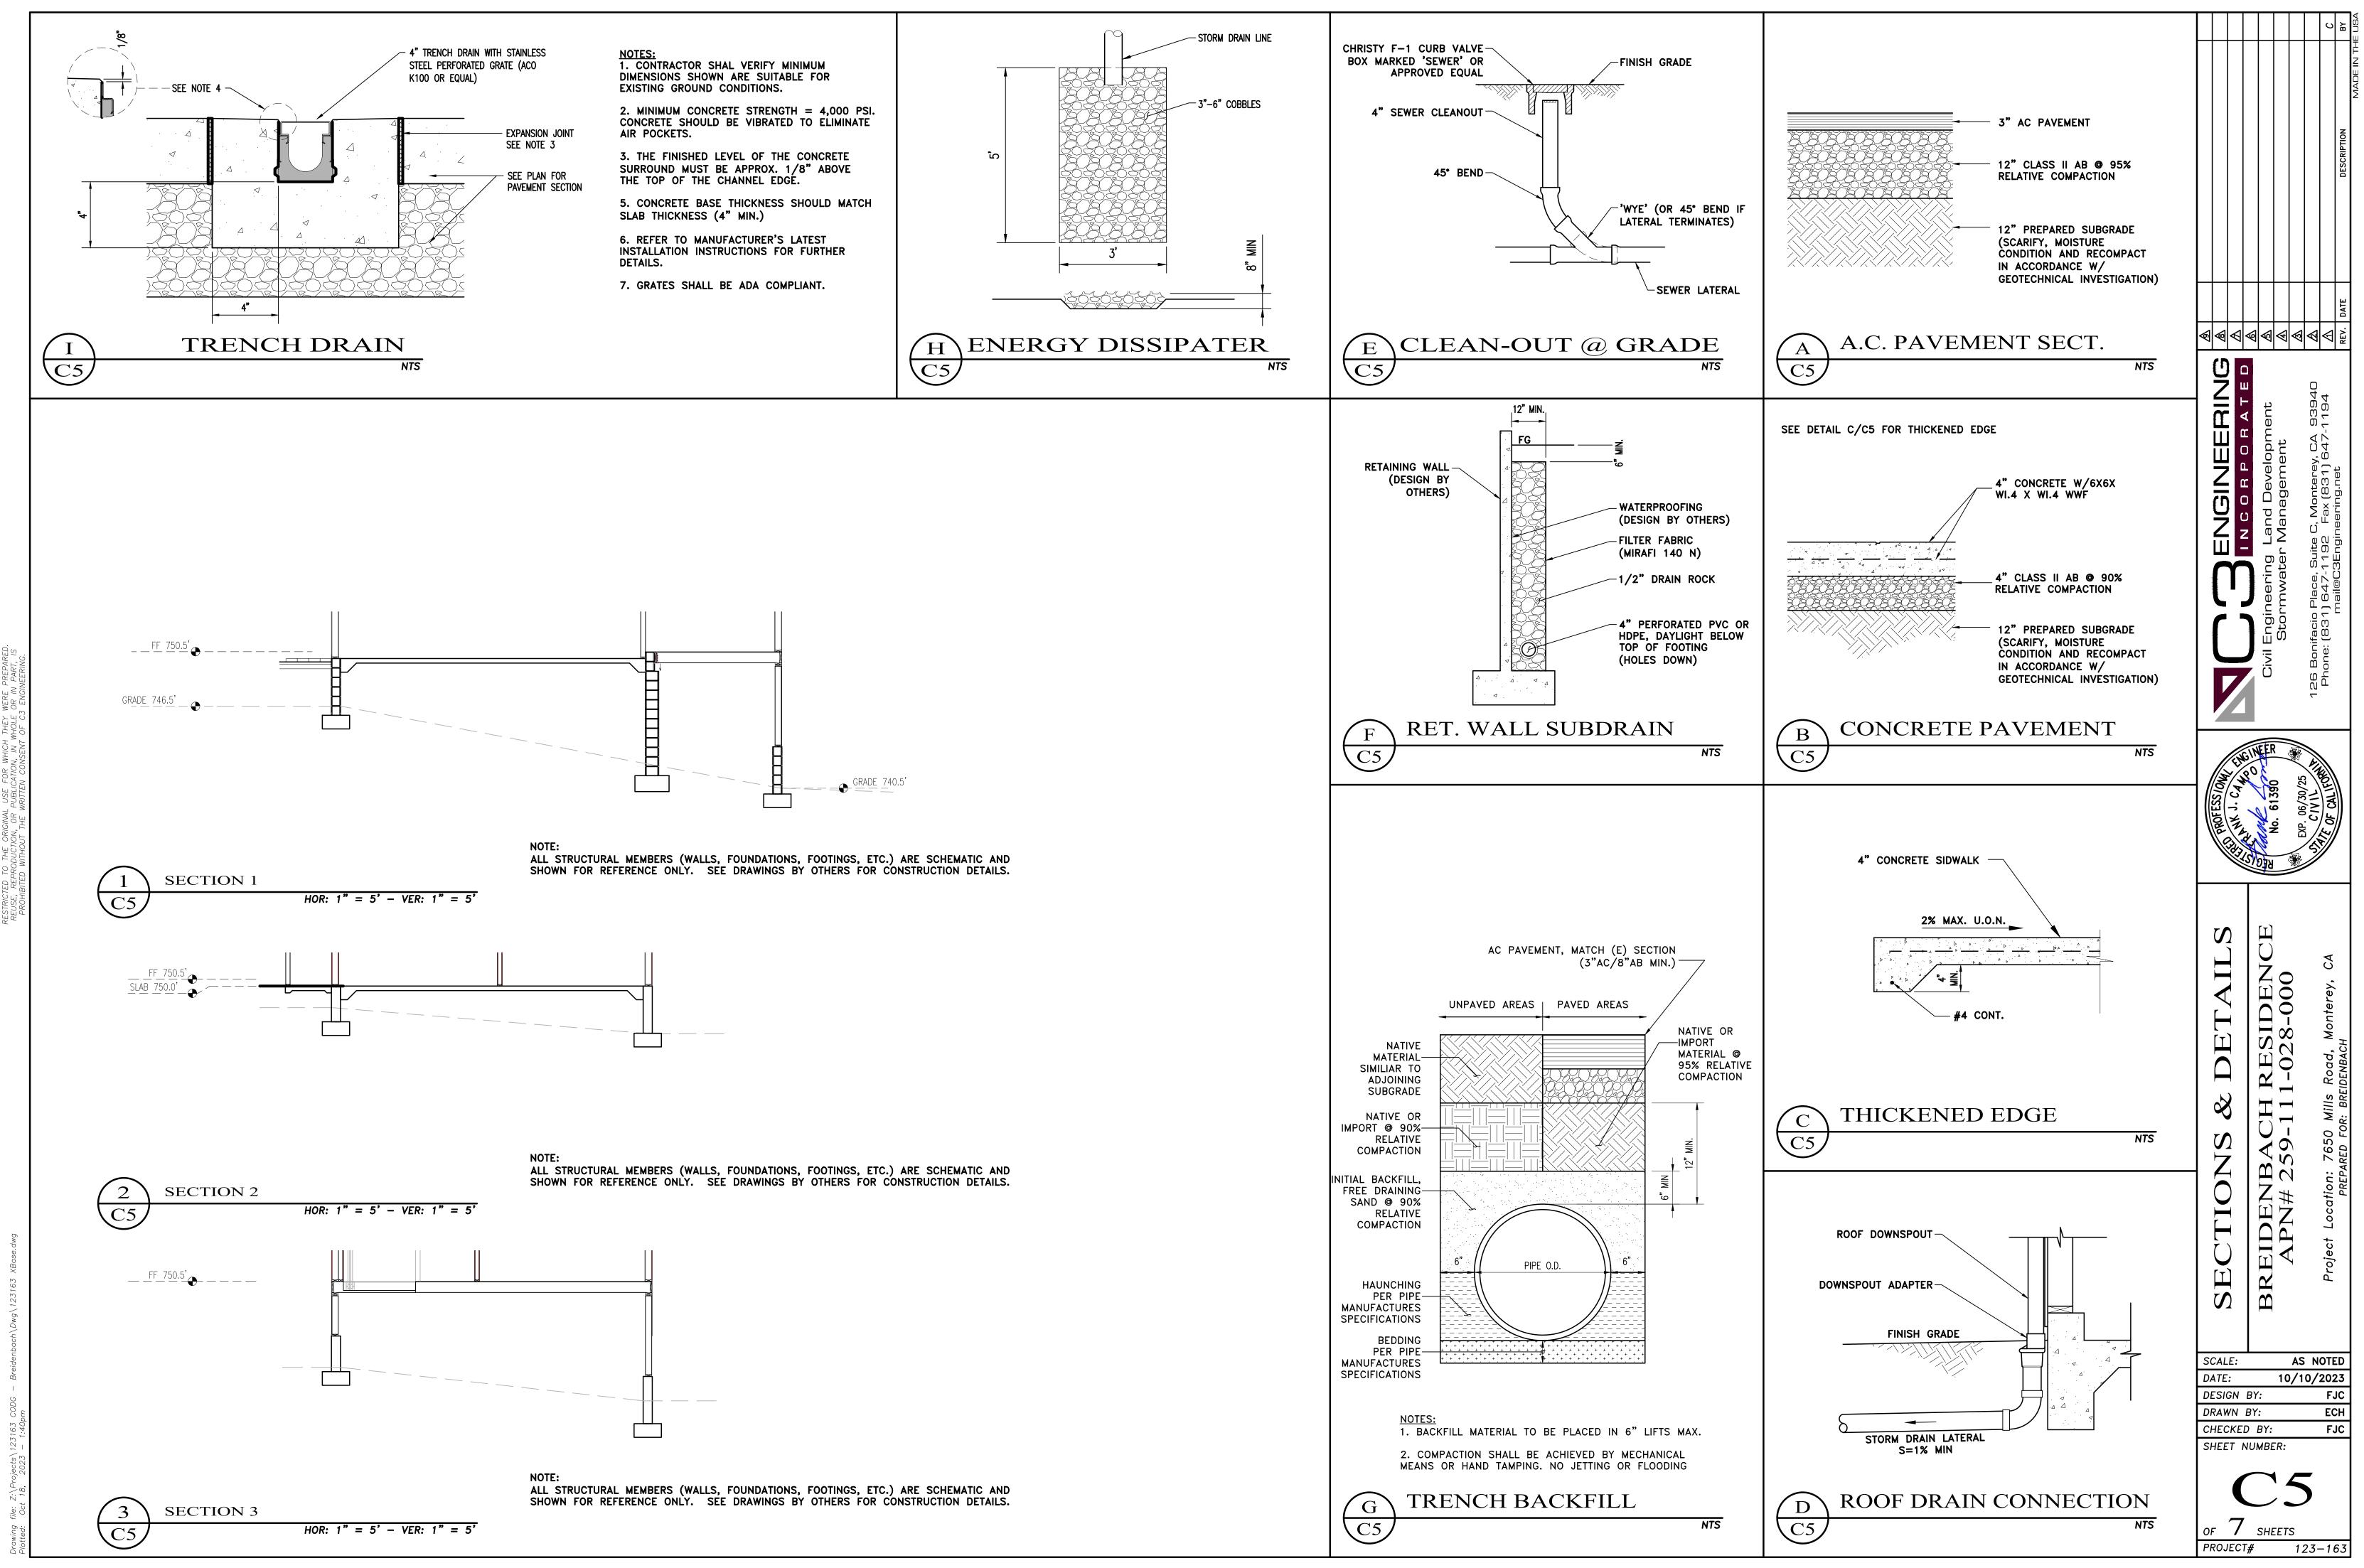

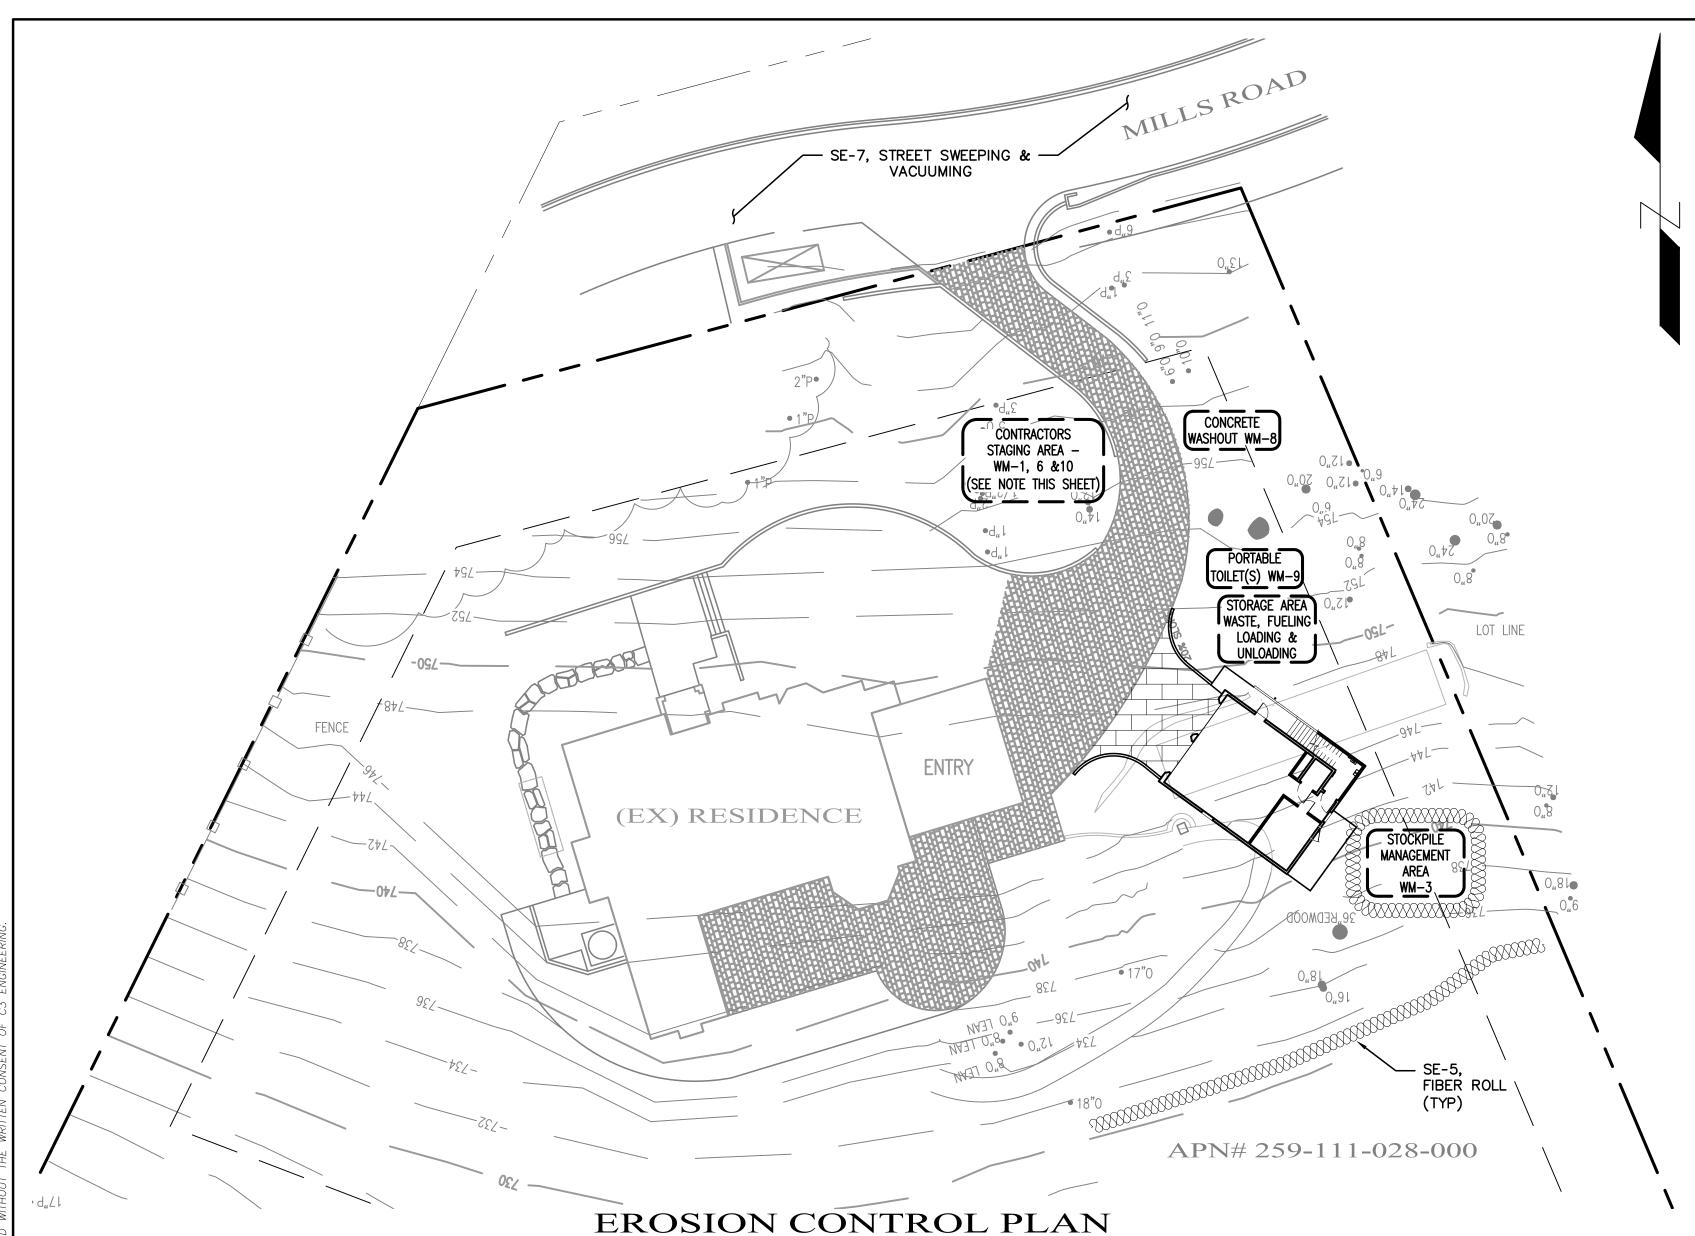

**BMP'S** 

- EROSION CONTROL: EC-1 SCHEDULING EC-2 PRESERVATION OF EXISTING VEGETATION EC-3 HYDRAULIC MULCH EC-4 HYDROSEEDING EC-8 WOOD MULCHING EC-16 NON-VEGETATIVE STABILIZATION
- <u>SEDIMENT CONTROL:</u> SE-1 SILT FENCE
- SE-2 SEDIMENT BASINS SE-3 SEDIMENT TRAP SE-5 FIBER ROLL
- SE-6 GRAVEL BAG BERM SE-7 STREET SWEEPING AND VACUUMING SE-8 GRAVEL BAG BARRIER SE-9 STRAW BALE BARRIER
- SE-10 STORM DRAIN INLET PROTECTION SE-13 COMPOST SOCKS AND BERMS SE-14 BIOFILTER BAGS
- TRACKING CONTROL: TC-1 STABILIZED CONSTRUCTION ENTRANCE/EXIT TC-3 ENTRANCE/OUTLET TIRE WASH
- <u>WIND EROSION CONTROL:</u> WE-1 WIND EROSION CONTROL

SANITARY WASTE MANAGEMENT.

- NON-STORM WATER MANAGEMENT: NS-1 WATER CONSERVATION PRACTICES NS-2 DEWATERING OPERATIONS NS-3 PAVING AND GRINDING OPERATIONS NS-6 ILLICIT CONNECTION/DISCHARGE NS-7 POTABLE WATER/IRRIGATION
- NS-8 VEHICLE AND EQUIPMENT CLEANING
- NS-9 VEHICLE AND EQUIPMENT FUELING NS-10 VEHICLE AND EQUIPMENT MAINTENANCE
- NS-12 CONCRETE CURING NS-13 CONCRETE FINISHING
- NS-14 MATERIAL AND EQUIPMENT USE
- WASTE MANAGEMENT AND MATERIAL POLLUTION CONTROL: WM-1 MATERIAL DELIVERY AND STORAGE
- WM-2 MATERIAL USED WM-3 STOCKPILE MANAGEMENT
- WM-4 SPILL PREVENTION AND CONTROL WM-5 SOLID WASTE MANAGEMENT
- WM-6 HAZARDOUS WASTE MANAGEMENT WM-7 CONTAMINATED SOIL MANAGEMENT
- WM-8 CONCRETE WASTE MANAGEMENT WM-9 SANITARY/SEPTIC WASTE MANAGEMENT
- WM—10 LIQUID WASTE MANAGEMENT REFER TO THE CASQA BMP HANDBOOK FOR BMP FACT SHEETS. SWPPP WDID#XXXXXXXXXX

NOTE: CONTRACTORS STAGING AREA DESIGNATED FOR FOLLOWING STORM WATER BEST MANAGEMENT PRACTICES: SCHEDULING, WATER CONSERVATION PRACTICES, VEHICLE & EQUIPMENT CLEANING, VEHICLE & EQUIPMENT MAINTENANCE, MATERIAL DELIVERY & STORAGE, STOCKPILE MANAGEMENT, SPILL PREVENTION &

CONTROL, SOLID WASTE MANAGEMENT, HAZARDOUS WASTE MANAGEMENT, CONCRETE WASTE MANAGEMENT,

# LEGEND

INLET PROTECTION, (SEE D/C7) PROPOSED DRAINAGE FLOW

FIBER ROLL (SEE A/C7)

1			
		1	$\frown$

-XXXXXXXXXXXXXXXXXXXXXXXXXXXXX

# "=30'

## INSPECTIONS

PRIOR TO COMMENCEMENT OF ANY LAND DISTURBANCE, THE OWNER/APPLICANT SHALL SCHEDULE AN INSPECTION WITH (RMA-ENVIRONMENTAL SERVICES) TO ENSURE ALL NECESSARY SEDIMENT CONTROLS ARE IN PLACE AND THE PROJECT IS COMPLIANT WITH MONTEREY COUNTY REGULATIONS.

DURING CONSTRUCTION. THE OWNER/APPLICANT SHALL SCHEDULE AN INSPECTION WITH (RMA-ENVIRONMENTAL SERVICES) TO INSPECT DRAINAGE DEVICE INSTALLATION, REVIEW THE MAINTENANCE AND EFFECTIVENESS OF BMPS INSTALLED, AND TO VERIFY THAT POLLUTANTS OF CONCERN ARE NOT DISCHARGED FROM THE SITE. AT THE TIME OF THE INSPECTION, THE APPLICANT SHALL PROVIDE CERTIFICATION THAT ALL NECESSARY GEOTECHNICAL INSPECTIONS HAVE BEEN COMPLETED TO THAT POINT.

PRIOR TO FINAL INSPECTION, THE OWNER/APPLICANT SHALL SCHEDULE AN INSPECTION WITH (RMA-ENVIRONMENTAL SERVICES) TO ENSURE THAT ALL DISTURBED AREAS HAVE BEEN STABILIZED AND THAT ALL TEMPORARY EROSION AND SEDIMENT CONTROL MEASURES THAT ARE NO LONGER NEEDED HAVE BEEN REMOVED.

PRIOR TO FINAL INSPECTION, THE OWNER/APPLICANT SHALL PROVIDE (RMA-ENVIRONMENTAL SERVICES) A LETTER FROM A LICENSED PRACTITIONER.

# EROSION CONTROL NOTES

- 1. ALL POLLUTANTS AND THEIR SOURCES, INCLUDING SOURCES OF SEDIMENT ASSOCIA CONSTRUCTION, CONSTRUCTION SITE EROSION AND ALL OTHER ACTIVITIES ASSOCIATE CONSTRUCTION ACTIVITY SHALL BE CONTROLLED.
- 2. ALL NON-STORM WATER DISCHARGES SHALL BE IDENTIFIED AND EITHER ELIMINATED TREATED.
- 3. SITE BMPS SHALL BE IMPLEMENTED TO REDUCE OR ELIMINATE POLLUTANTS IN STOP DISCHARGES AND AUTHORIZED NON-STORM WATER DISCHARGES FROM CONSTRUCTION
- 4. BEST MANAGEMENT PRACTICES (BMPS) TO BE IMPLEMENTED BY THE PROJECT ARE CATEGORY. FACT SHEETS, AND DETAILS FOR THE BMPS SELECTED FOR THIS PROJECT IN THE CASQA STORMWATER BEST MANAGEMENT PRACTICE HANDBOOK.
- 5. DETAILED, SITE-SPECIFIC LISTING OF POTENTIAL SOURCES OF STORMWATER POLLUTION IS STORMWATER CONTROL PLAN AND OR THE SWPPP.
- 6. ACCESS ROADS SHALL BE CLEANED (SWEPT) DAILY (IF NECESSARY) AND PRIOR TO
- 7. DUMPSTERS SHALL BE COVERED NIGHTLY AND PROTECTED FROM RAIN AND SHALL CONTAINMENT.

THE FOLLOWING STANDARD BMPS SHALL BE IMPLEMENTED IN ACCORDANCE WITH THE STORMWATER MANAGEMENT PROGRAM:

### PAINTING: 1. MINIMIZE USE OF OIL-BASED PAINTS

2. STORE SOLVENTS AND PAINTS IN ORIGINAL CONTAINERS OR OTHER FIRE MARSHAL CONTAINER. 3. SPENT SOLVENTS ARE HAZARDOUS WASTES. STORE SPENT SOLVENTS IN APPROVED REUSE SOLVENTS AS MUCH AS POSSIBLE AND USE PAINTS AS MUCH AS POSSIBLE RA DISPOSING OF THEM. DISPOSE OF SPENT SOLVENTS AND UNUSABLE PAINT AS A HAZAF

4. NEVER CLEAN PAINT EQUIPMENT WHERE SOLVENTS, PAINT OR CONTAMINATED RINSE THE STORM DRAIN SYSTEM.

### PLASTERING/STUCCO/TILING/SITE-MIXED CONCRETE:

1. STORE PLASTER AND CEMENT IN COVERED AREAS AND KEEP THEM OUT OF THE WII 2. CONSERVE MATERIALS. DON'T MIX MORE PRODUCT THAN CAN BE USED BEFORE IT I 3. IF THERE IS LEFT OVER PRODUCT, PLACE THE EXCESS IN AN EARTHEN DEPRESSION PRODUCT CURE AND DISPOSE OF AS REGULAR REFUSE.

4. ALL RINSE WATER IS TO BE PLACED IN AN EARTHEN DEPRESSION CAPABLE OF HOLD WATER AS WELL AS ANY RAIN WATER THAT WOULD FALL/RUN INTO THE DEPRESSION.

### READY-MIXED CONCRETE:

1. HAVE AN EARTHEN DEPRESSION DUG PRIOR TO THE ARRIVAL OF THE READY-MIX 2. IF A PUMP IS USED, PLACE THE ENTIRE PUMP PRIMING FLUID AND REJECT CONCRI DEPRESSION.

3. PLACE ALL SPILLED CONCRETE AND CHUTE WASH WATER IN THE DEPRESSION. 4. ALL TRUCK AND PUMP RINSE WATER IS TO BE TAKEN BACK TO THE READY-MIX B

TREATMENT/RECYCLING. 5. BEFORE CREATING AN EXPOSED AGGREGATE FINISH, CAREFULLY PLAN AND PREPARE SLURRY THAT IS WASHED OFF FROM ENTERING THE STORM DRAIN SYSTEM AND GUTTER

### EARTH MOVING/GRADING: 1. REMOVE EXISTING VEGETATION ONLY WHEN NECESSARY.

2. PLANT TEMPORARY VEGETATION WHEN SLOPE HAVE BEEN DISTURBED BUT CONSTRUCT

 
ONGOING DURING PERIODS OF RAIN 3. PROTECT DOWN SLOPE DRAINAGE COURSES BY RECOGNIZED METHODS SUCH AS TH HANDBOOK.

4. USE CHECK DAMS OR DITCHES TO DIVERT WATER AROUND EXCAVATIONS.

5. COVER STOCKPILES OF EXCAVATED SOIL WITH TARPS. 6. SCHEDULE GRADING ACTIVITIES DURING DRY PERIODS.


DTES	EROSION CONTROL NOTES			BY C
Ciated with Iated with	1. THE CONTRACTOR SHALL TAKE ALL NECESSARY MEASURES TO PREVENT AIRBORNE DUST FROM BECOMING A NUISANCE TO NEIGHBORING PROPERTIES. THE CONTRACTOR SHALL CONFORM TO THE STANDARDS FOR DUST-CONTROL AS ESTABLISHED BY THE AIR QUALITY MAINTENANCE DISTRICT. DUST CONTROL MEASURES TO BE IMPLEMENTED INCLUDE BUT ARE NOT LIMITED TO THE FOLLOWING:			
TED, CONTROLLED, OR STORM WATER CTION ACTIVITY.	<ul> <li>A. PROVIDE EQUIPMENT AND MANPOWER REQUIRED FOR WATERING ALL EXPOSED OR DISTURBED EARTH. SUFFICIENT WATERING TO CONTROL DUST IS REQUIRED AT ALL TIMES.</li> <li>B. COVER STOCKPILES OF DEBRIS, SOIL, OR OTHER MATERIALS WHICH MAY CONTRIBUTE TO AIRBORNE DUST.</li> </ul>			
RE LISTED BY DJECT, CAN BE FOUND	C. KEEP CONSTRUCTION AREAS AND ADJACENT STREET FREE OF MUD AND DUST. D. LANDSCAPE, SEED, OR COVER PORTIONS OF THE SITE AS SOON AS CONSTRUCTION IS COMPLETE.			DESCRIPTION
is provided in the	THE CONTRACTOR SHALL ASSUME LIABILITY FOR CLAIMS RELATED TO WIND BLOWN MATERIAL. IF THE DUST CONTROL IS INADEQUATE AS DETERMINED BY THE CITY, THE CONSTRUCTION WORK SHALL BE TERMINATED UNTIL CORRECTIVE MEASURES ARE TAKEN.			
TO ANY RAIN EVENT.	2. THE CONTRACTOR SHALL TAKE ALL NECESSARY MEASURES TO KEEP STREETS AND ROADS FREE FROM DIRT AND DEBRIS. SHOULD ANY DIRT OR DEBRIS BE DEPOSITED IN THE PUBLIC RIGHT-OF-WAY, THE CONTRACTOR SHALL REMOVE IT IMMEDIATELY.			
ll have secondary Ie monterey regional	3. ALL CUT AND FILL SLOPES EXPOSED DURING CONSTRUCTION SHALL BE COVERED, SEEDED OR OTHERWISE TREATED TO CONTROL EROSION WITHIN 48 HOURS AFTER GRADING. CONTRACTOR SHALL RE-VEGETATE SLOPES AND ALL DISTURBED AREAS THROUGH AN APPROVED PROCESS AS DETERMINED BY THE COUNTY. THIS MAY CONSIST OF EFFECTIVE PLANTING OF RYE GRASS, BARLEY OR SOME OTHER FAST GERMINATING SEED.			ATE
L APPROVED	4. DURING WINTER OPERATIONS (BETWEEN OCTOBER 1ST AND APRIL 30TH), THE FOLLOWING MEASURES MUST BE TAKEN:	<u></u>	<u></u>	REV. D
ed containers. Rather Than Izardous Waste. Ise Water can enter Wind. It Hardens.	<ul> <li>A. VEGETATION REMOVAL SHALL NOT PRECEDE SUBSEQUENT GRADING OR CONSTRUCTION ACTIVITIES BY MORE THAN 15 DAYS. DURING THIS PERIOD, EROSION AND SEDIMENT CONTROL MEASURES SHALL BE IN PLACE. DISTURBED SURFACES NOT INVOLVED IN THE IMMEDIATE OPERATIONS MUST BE PROTECTED BY MULCHING AND/OR OTHER EFFECTIVE MEANS OF SOIL PROTECTION.</li> <li>B. ALL ROADS AND DRIVEWAYS SHALL HAVE DRAINAGE FACILITIES SUFFICIENT TO PREVENT EROSION ON OR ADJACENT TO THE ROADWAY OR THE DOWNHILL PROPERTIES.</li> <li>C. RUN-OFF FROM THE SITE SHALL BE DETAINED OR FILTERED BY BERMS, VEGETATED FILTER STRIPS AND/OR CATCH BASINS TO PREVENT THE ESCAPE OF SEDIMENT FROM THE DISTURBED AREA OR SITE. THESE DRAINAGE CONTROL MEASURES MUST BE MAINTAINED BY THE CONTRACTOR AS NECESSARY TO ACHIEVE THEIR PURPOSE THROUGHOUT THE LIFE OF THE PROJECT.</li> </ul>		opment	, CA 93940 647-1194
sion. Let the Holding the Rinse N.	<ul> <li>D. EROSION AND SEDIMENT CONTROL MEASURES SHALL BE MAINTAINED AND IN PLACE AT THE END OF EACH DAY AND CONTINUOUSLY CHECKED THROUGHOUT THE LIFE OF THE PROJECT DURING WINTER OPERATIONS.</li> <li>E. THE GRADING INSPECTOR MAY STOP OPERATIONS DURING PERIODS OF INCLEMENT WEATHER IF</li> </ul>		nd Developn anagement	C, Monterey, Fax (831) 6 neering.net
( TRUCK. ICRETE IN THE	EROSION PROBLEMS ARE NOT BEING CONTROLLED ADEQUATELY. 5. IF VEGETATION REMOVAL TAKES PLACE PRIOR TO A GRADING OPERATION AND THE ACTUAL GRADING		Land Mana	C, A Fax ineeri
BATCH PLANT FOR	DOES NOT BEGIN WITHIN 30 DAYS FROM THE DATE OF REMOVAL, THEN THAT AREA SHALL BE PLANTED UNDER THE PROVISION OF SECTION 16.08.340 TO CONTROL EROSION. NO VEGETATION REMOVAL OR GRADING WILL BE ALLOWED WHICH WILL RESULT IN SILTATION OF WATER COURSES OR UNCONTROLLABLE			, Suite C -1192 33Engine
are to prevent the Iters.	EROSION. 6. SOIL COMPACTION FOR AREAS THAT WILL REMAIN PERVIOUS OR ARE TO BE USED FOR STORMWATER		Engineering Stormwate	lace, 647- ail@C
	CONTROL MEASURES (SCM) SHALL BE MINIMIZED. 7. ALL FINISHED SLOPES, OPEN SPACE, UTILITY BACKFILL AND OR COMPLETED LOTS THAT ARE NOT		ngin itorr	26 Bonifacio Place, Phone: (831) 647- mail@C
RUCTION IS STILL THOSE IN THE CASQA	SCHEDULED TO BE RE-DISTURBED FOR MINIMALLY 14 DAYS SHALL BE PROTECTED WITH EFFECTIVE SOIL COVER. 8. SOIL STOCKPILES AREAS SHALL BE PROTECTED AGAINST EROSION.			30nifa ne: (8
		PROFESSION	EXP. 06/30/25	CIVIL CIVIL
		EROSION AND SEDIMENT CONTROL PLAN	BREIDENBACH RESIDENCE APN# 259-111-028-000	Project Location: 7650 Mills Road, Monterey, CA PREPARED FOR: BREIDENBACH
		SCALE: DATE: DESIGN DRAWN CHECKEE SHEET N	<b>10/1</b> ( BY: BY: D BY:	NOTED 0/2023 FJC ECH FJC

	0		Ę	5		1	0	
	Sco	ale	1"	=	5	5'		



Drawing file: Z:\Projects\123163\_C0DG — Breidenbach\Dwg\123163\_XBase.dwg Diatrod: 0.4-18\_2023\_\_\_\_140000

THE USE OF THESE DRAWINGS AND SPECIFICATIONS SHALL BE RESTRICTED TO THE ORIGINAL USE FOR WHICH THEY WERE PREPARED. REUSE, REPRODUCTION, OR PUBLICATION, IN WHOLE OR IN PART, IS PROHIBITED WITHOUT THE WRITTEN CONSENT OF C3 ENGINEERING.

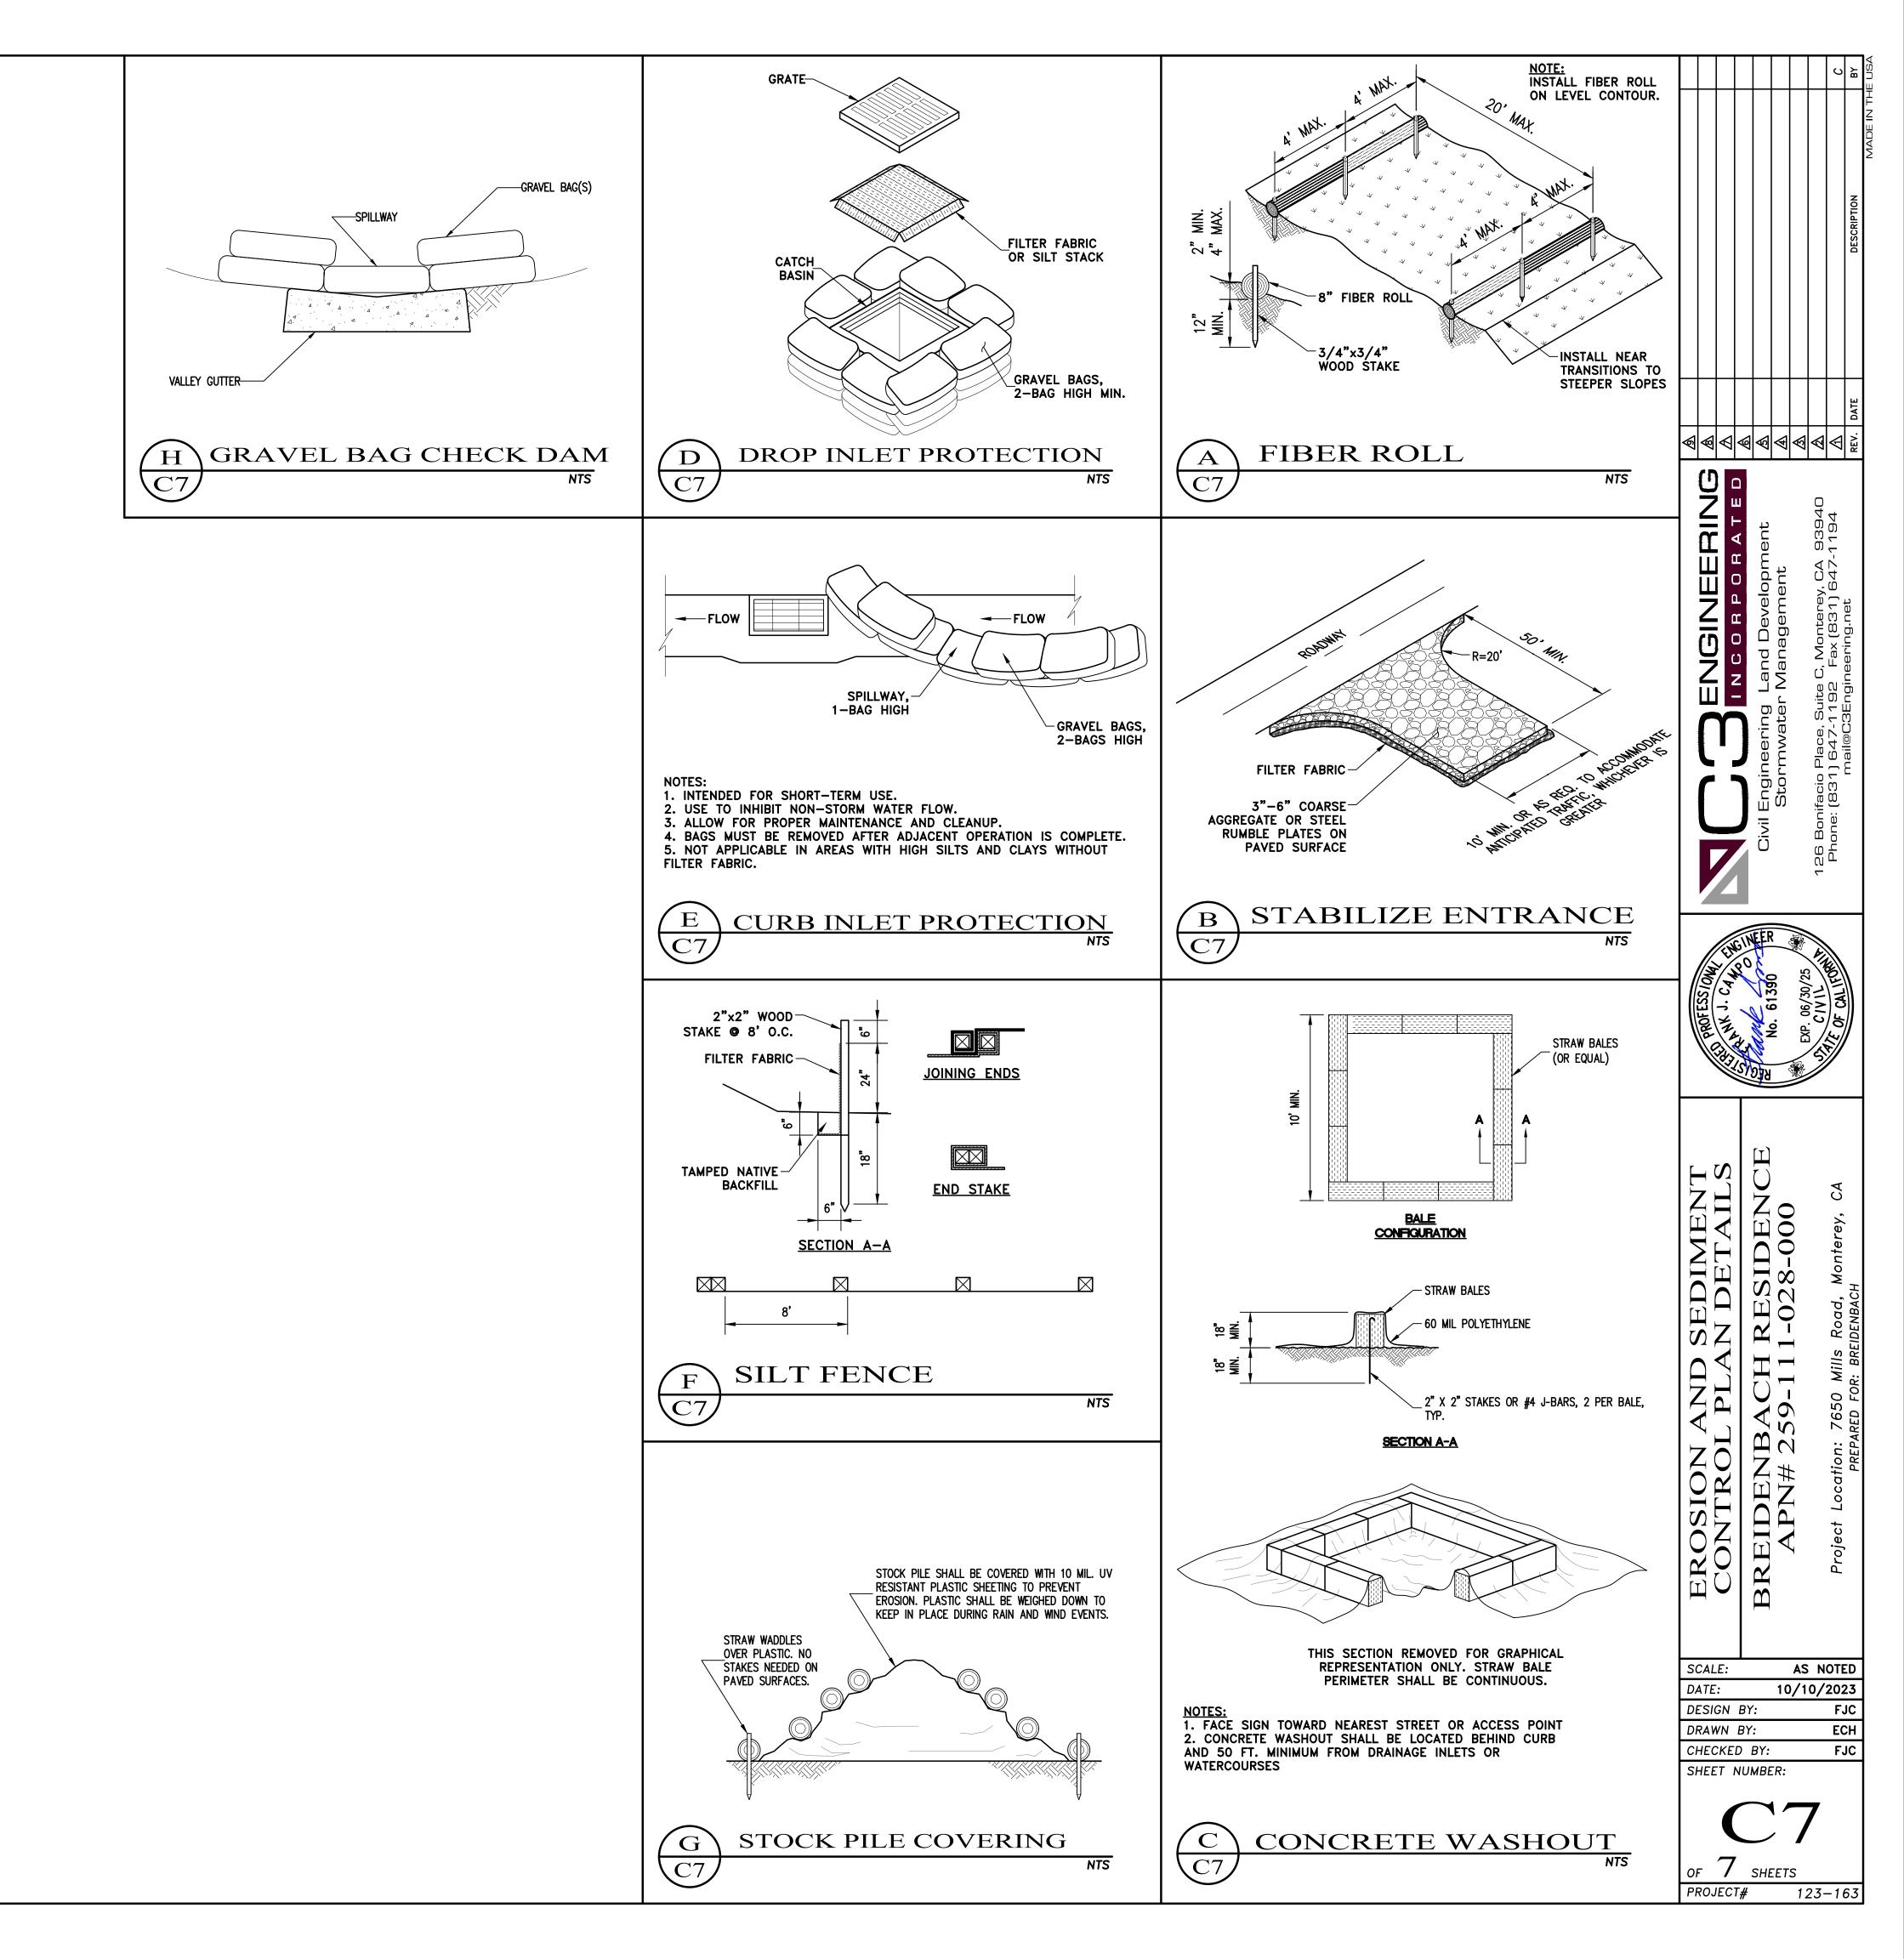

This page intentionally left blank