


Exhibit J

This page intentionally left blank.

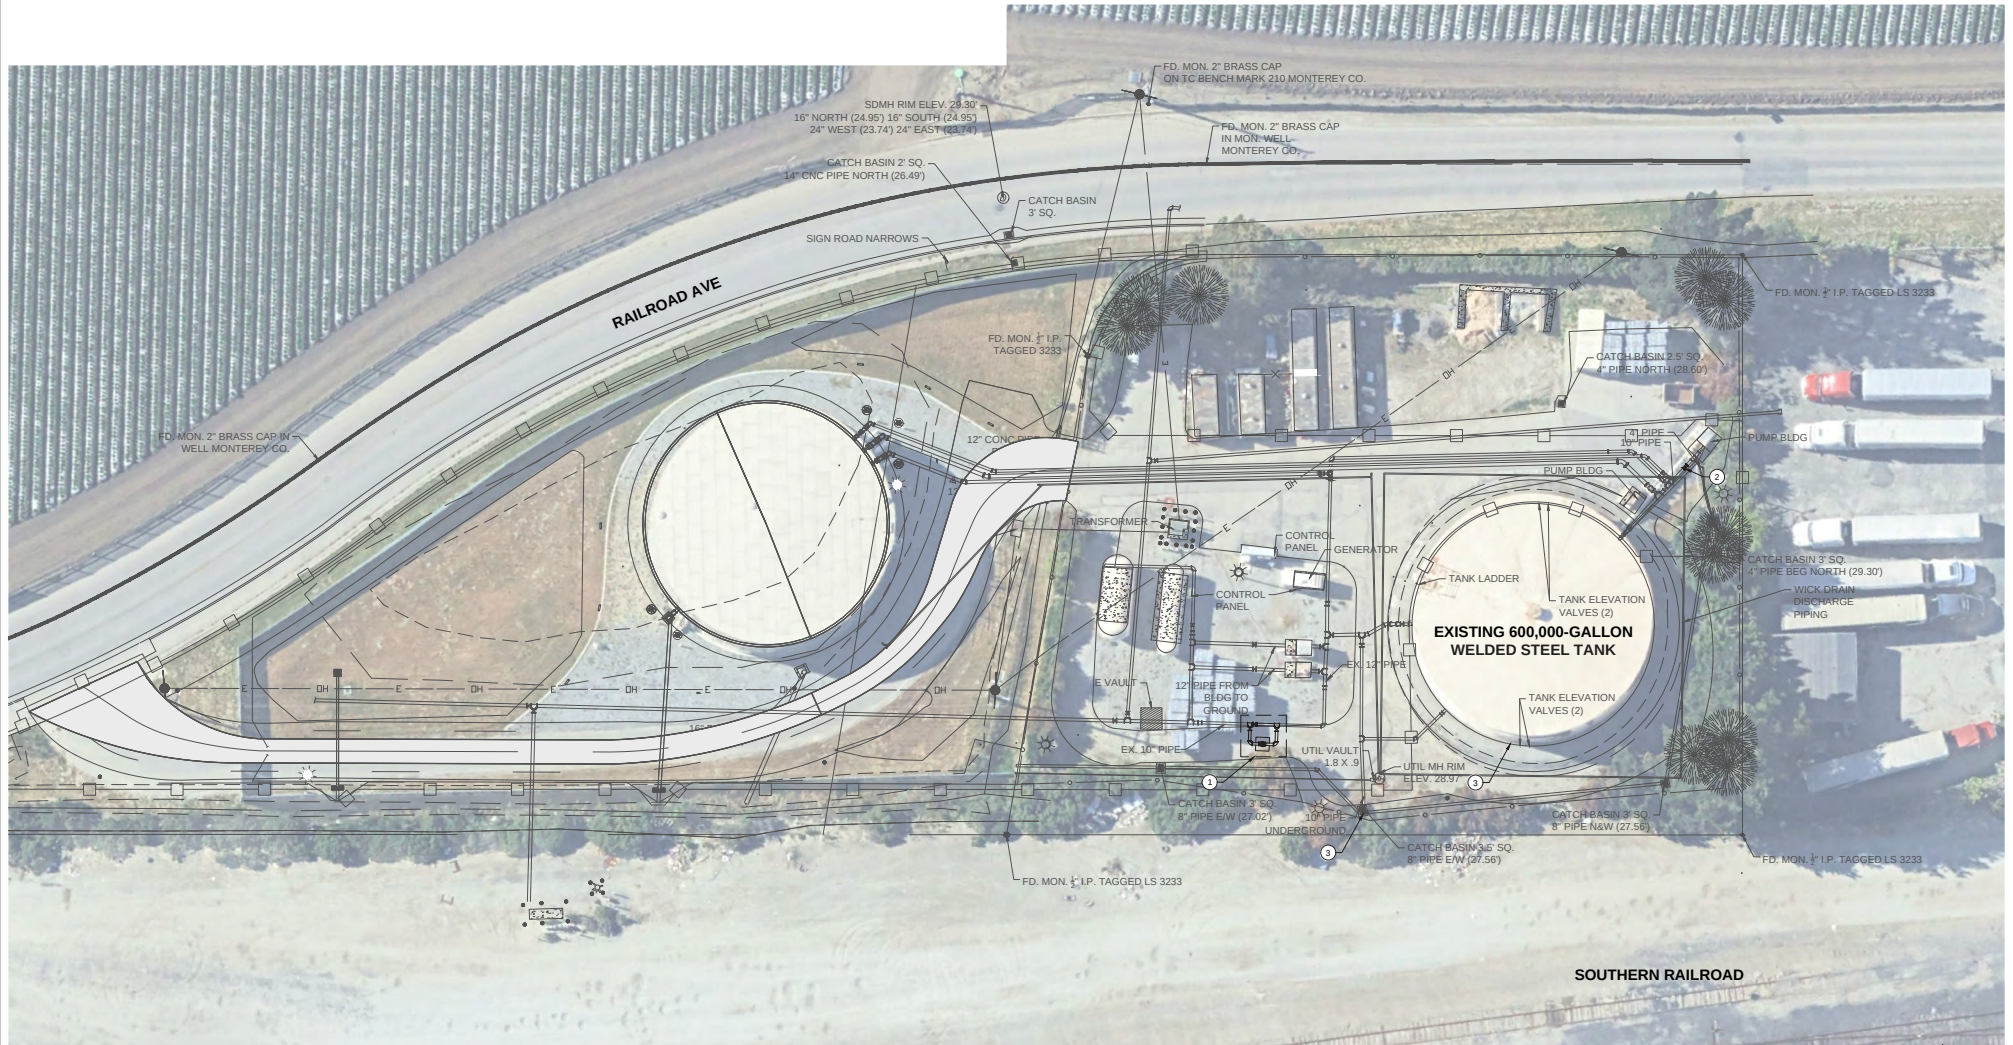

CONSTRUCTION NOTES

- ① INSTALL 4'-5" X 4'-5" BYPASS VALVE VAULT PER DRAWING C-104
- ② REMOVE AND REPLACE 10" ELECTROMAGNETIC FLOW METER (FLG)
- ③ SEE DRAWING M-301 FOR TANK REHABILITATION

20' 10' 0' 10' 20'
SCALE: 1" = 20'



Source: MNS, June 2025


Title: **Site Plan - PWS Water Storage Tank**

Date 6/27/2025
Scale N/A
Project 2023.47



Monterey | San Jose
Denise Duffy and Associates, Inc.
Environmental Consultants Resource Planners
947 Cass Street, Suite 5
Monterey, CA 93940
(831) 373-4341

Figure
6a

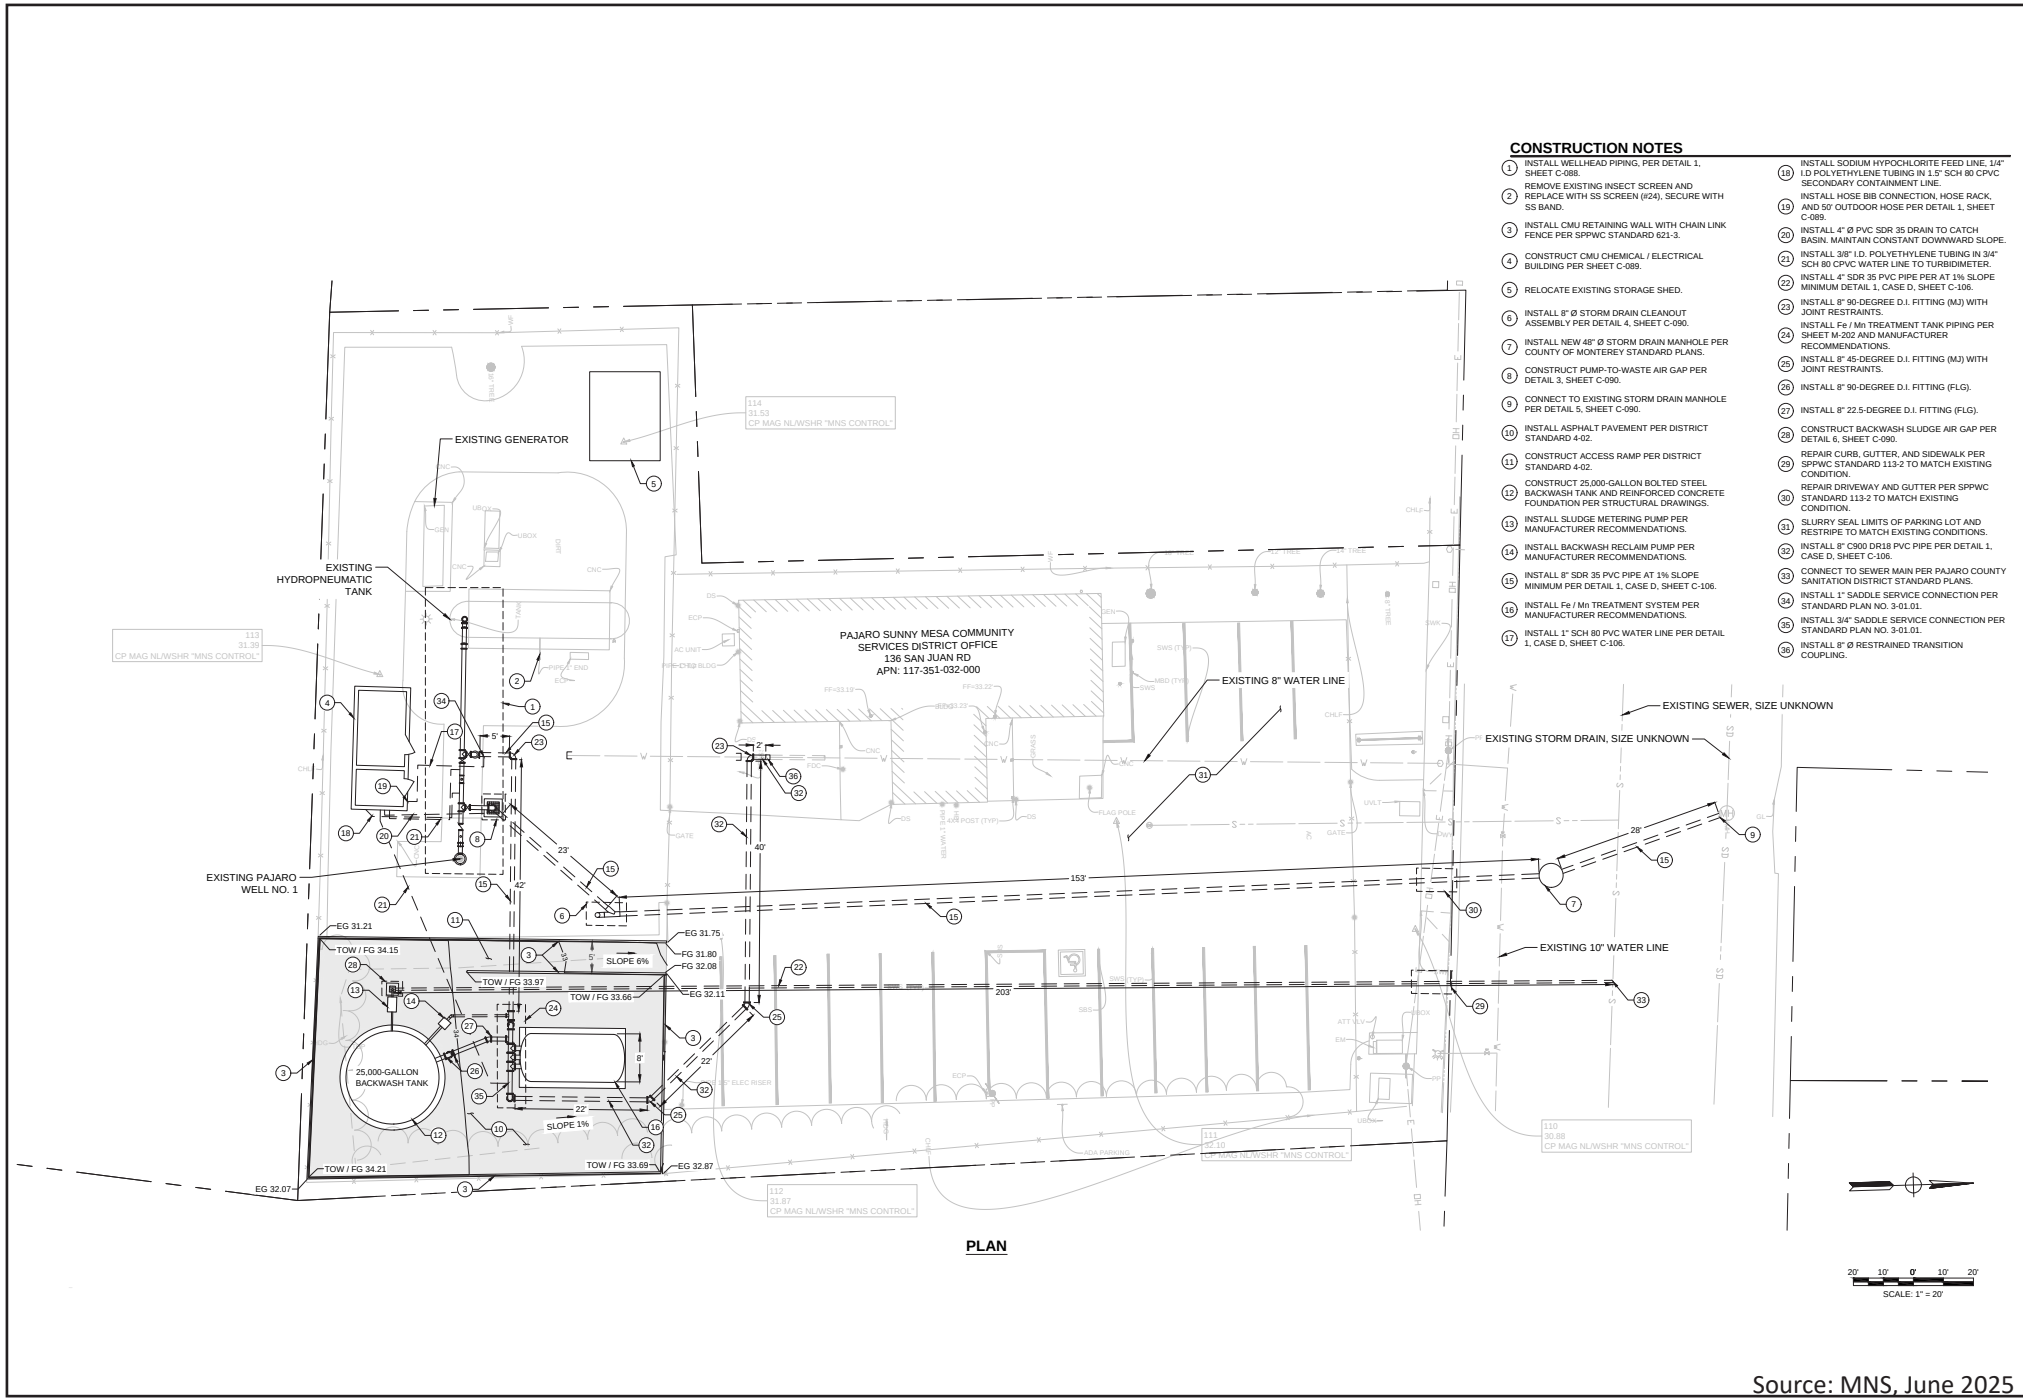

CONSTRUCTION NOTES

1. INSTALL WELLHEAD PIPING, PER DETAIL 1, SHEET C-088.
2. REMOVE EXISTING INSECT SCREEN AND REPLACE WITH SS SCREEN (#24), SECURE WITH SS BAND.
3. INSTALL CMU RETAINING WALL WITH CHAIN LINK FENCE PER SPPWC STANDARD 621-3.
4. CONSTRUCT CMU CHEMICAL / ELECTRICAL BUILDING PER SHEET C-089.
5. RELOCATE EXISTING STORAGE SHED.
6. INSTALL 8" Ø STORM DRAIN CLEANOUT ASSEMBLY PER DETAIL 4, SHEET C-090.
7. INSTALL NEW 48" Ø STORM DRAIN MANHOLE PER COUNTY OF MONTEREY STANDARD PLANS.
8. CONSTRUCT PUMP-TO-WASTE AIR GAP PER DETAIL 3, SHEET C-090.
9. CONNECT TO EXISTING STORM DRAIN MANHOLE PER DETAIL 5, SHEET C-090.
10. INSTALL ASPHALT PAVEMENT PER DISTRICT STANDARD 4-02.
11. CONSTRUCT ACCESS RAMP PER DISTRICT STANDARD 4-02.
12. CONSTRUCT 25,000-GALLON BOLTED STEEL BACKWASH TANK AND REINFORCED CONCRETE FOUNDATION PER STRUCTURAL DRAWINGS.
13. INSTALL SLUDGE METERING PUMP PER MANUFACTURER RECOMMENDATIONS.
14. INSTALL BACKWASH RECLAIM PUMP PER MANUFACTURER RECOMMENDATIONS.
15. INSTALL 8" SDR 35 PVC PIPE AT 1% SLOPE MINIMUM PER DETAIL 1, CASE D, SHEET C-106.
16. INSTALL Fe / Mn TREATMENT SYSTEM PER MANUFACTURER RECOMMENDATIONS.
17. INSTALL 1" SCH 80 PVC WATER LINE PER DETAIL 1, CASE D, SHEET C-106.
18. INSTALL SODIUM HYPOCHLORITE FEED LINE, 1/4" I.D. POLYETHYLENE TUBING IN 1.5" SCH 80 CPVC SECONDARY CONTAINMENT LINE.
19. INSTALL HOSE BIB CONNECTION, HOSE RACK, AND 50' OUTDOOR HOSE PER DETAIL 1, SHEET C-089.
20. INSTALL 4" Ø PVC SDR 35 DRAIN TO CATCH BASIN. MAINTAIN CONSTANT DOWNWARD SLOPE.
21. INSTALL 3/8" I.D. POLYETHYLENE TUBING IN 3/4" SCH 80 CPVC WATER LINE TO TURBIDIMETER.
22. INSTALL 4" SDR 35 PVC PIPE PER AT 1% SLOPE MINIMUM DETAIL 1, CASE D, SHEET C-106.
23. INSTALL 8" 90-DEGREE D.I. FITTING (MJ) WITH JOINT RESTRAINTS.
24. INSTALL Fe / Mn TREATMENT TANK PIPING PER SHEET M-202 AND MANUFACTURER RECOMMENDATIONS.
25. INSTALL 8" 45-DEGREE D.I. FITTING (MJ) WITH JOINT RESTRAINTS.
26. INSTALL 8" 90-DEGREE D.I. FITTING (FLG).
27. INSTALL 8" 22.5-DEGREE D.I. FITTING (FLG).
28. CONSTRUCT BACKWASH SLUDGE AIR GAP PER DETAIL 6, SHEET C-090.
29. REPAIR CURB, GUTTER, AND SIDEWALK PER SPPWC STANDARD 113-2 TO MATCH EXISTING CONDITION.
30. REPAIR DRIVEWAY AND GUTTER PER SPPWC STANDARD 113-2 TO MATCH EXISTING CONDITION.
31. SLURRY SEAL LIMITS OF PARKING LOT AND RESTRIPE TO MATCH EXISTING CONDITIONS.
32. INSTALL 8" C900 DRIB PVC PIPE PER DETAIL 1, CASE D, SHEET C-106.
33. CONNECT TO SEWER MAIN PER PAJARO COUNTY SANITATION DISTRICT STANDARD PLANS.
34. INSTALL 1" SADDLE SERVICE CONNECTION PER STANDARD PLAN NO. 3-01.01.
35. INSTALL 3/4" SADDLE SERVICE CONNECTION PER STANDARD PLAN NO. 3-01.01.
36. INSTALL 8" Ø RESTRAINED TRANSITION COUPLING.

Source: MNS, June 2025


Title: **Site Plan - Iron and Managanese**

Date: **6/27/2025**
 Scale: **N/A**
 Project: **2023.47**




Monterey | San Jose
Denise Duffy and Associates, Inc.
 Environmental Consultants Resource Planners
 947 Cass Street, Suite 5
 Monterey, CA 93940
 (831) 373-4341

Figure
6b

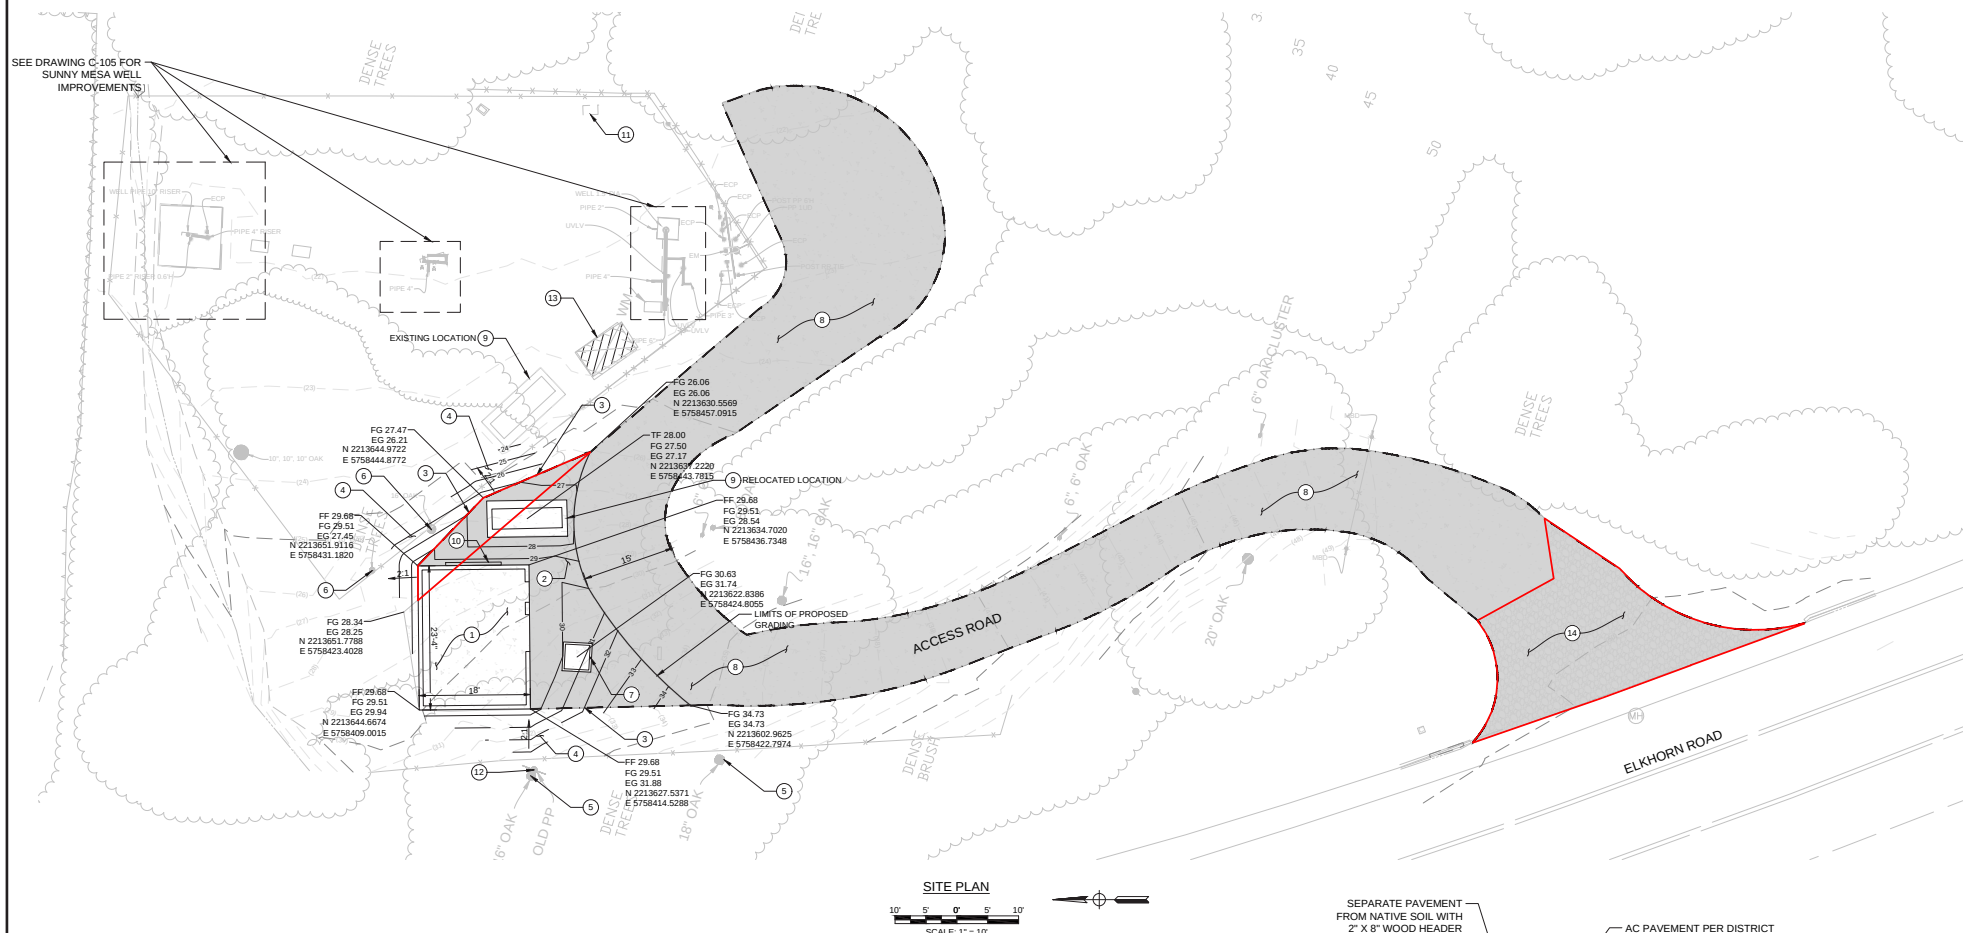

CONSTRUCTION NOTES

1. INSTALL ENCLOSED, PACKAGED DUPLEX BOOSTER PUMP STATION AND BUILDING PER DRAWING C-095.
2. GRADE FINISH SURFACE PER ELEVATIONS SHOWN AND DISTRICT STANDARD 4-02.
3. INSTALL WOOD HEADER PER DETAIL 1, THIS DRAWING.
4. DAYLIGHT NEW SURFACE AT 2:1 SLOPE TO MEET EXISTING GRADE.
5. PROTECT TREES IN PLACE.
6. REMOVE TREES.
7. INSTALL BYPASS VAULT PER DETAIL 3, DRAWING C-107.
8. REPLACE AC PAVEMENT ON ACCESS ROAD PER DISTRICT STANDARD 4-02. ELEVATIONS TO MATCH EXISTING CONDITIONS.
9. RELOCATE EXISTING GENERATOR. DEMOLISH AND REMOVE EXISTING CONCRETE PAD. CONSTRUCT NEW CONCRETE PAD PER STRUCTURAL DRAWINGS.
10. INSTALL ELECTRICAL PANEL MOUNTED ON BUILDING WALL PER ELECTRICAL DRAWINGS.
11. WATER METER AND LATERAL FOR TRI-COUNTY LANDSCAPE. LATERAL TO BE REROUTED AND METER RELOCATED.
12. PROTECT POWER POLE IN PLACE.
13. DEMOLISH AND REMOVE EXISTING STRUCTURE.
14. REPLACE GRAVEL WITH AC PAVEMENT ON ACCESS ROAD PER DISTRICT 4-02. ELEVATIONS TO MATCH EXISTING CONDITIONS.

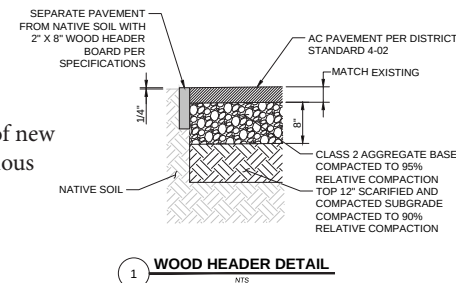

Limits of new
Impervious
Surface

Source: MNS, August 2025


Title: **Site Plan - Transmission Booster Pump**

Date: **8/12/2025**
Scale: **N/A**
Project: **2023.47**



Monterey | San Jose
Denise Duffy and Associates, Inc.
Environmental Consultants Resource Planners
947 Cass Street, Suite 5
Monterey, CA 93940
(831) 373-4341

Figure
6c

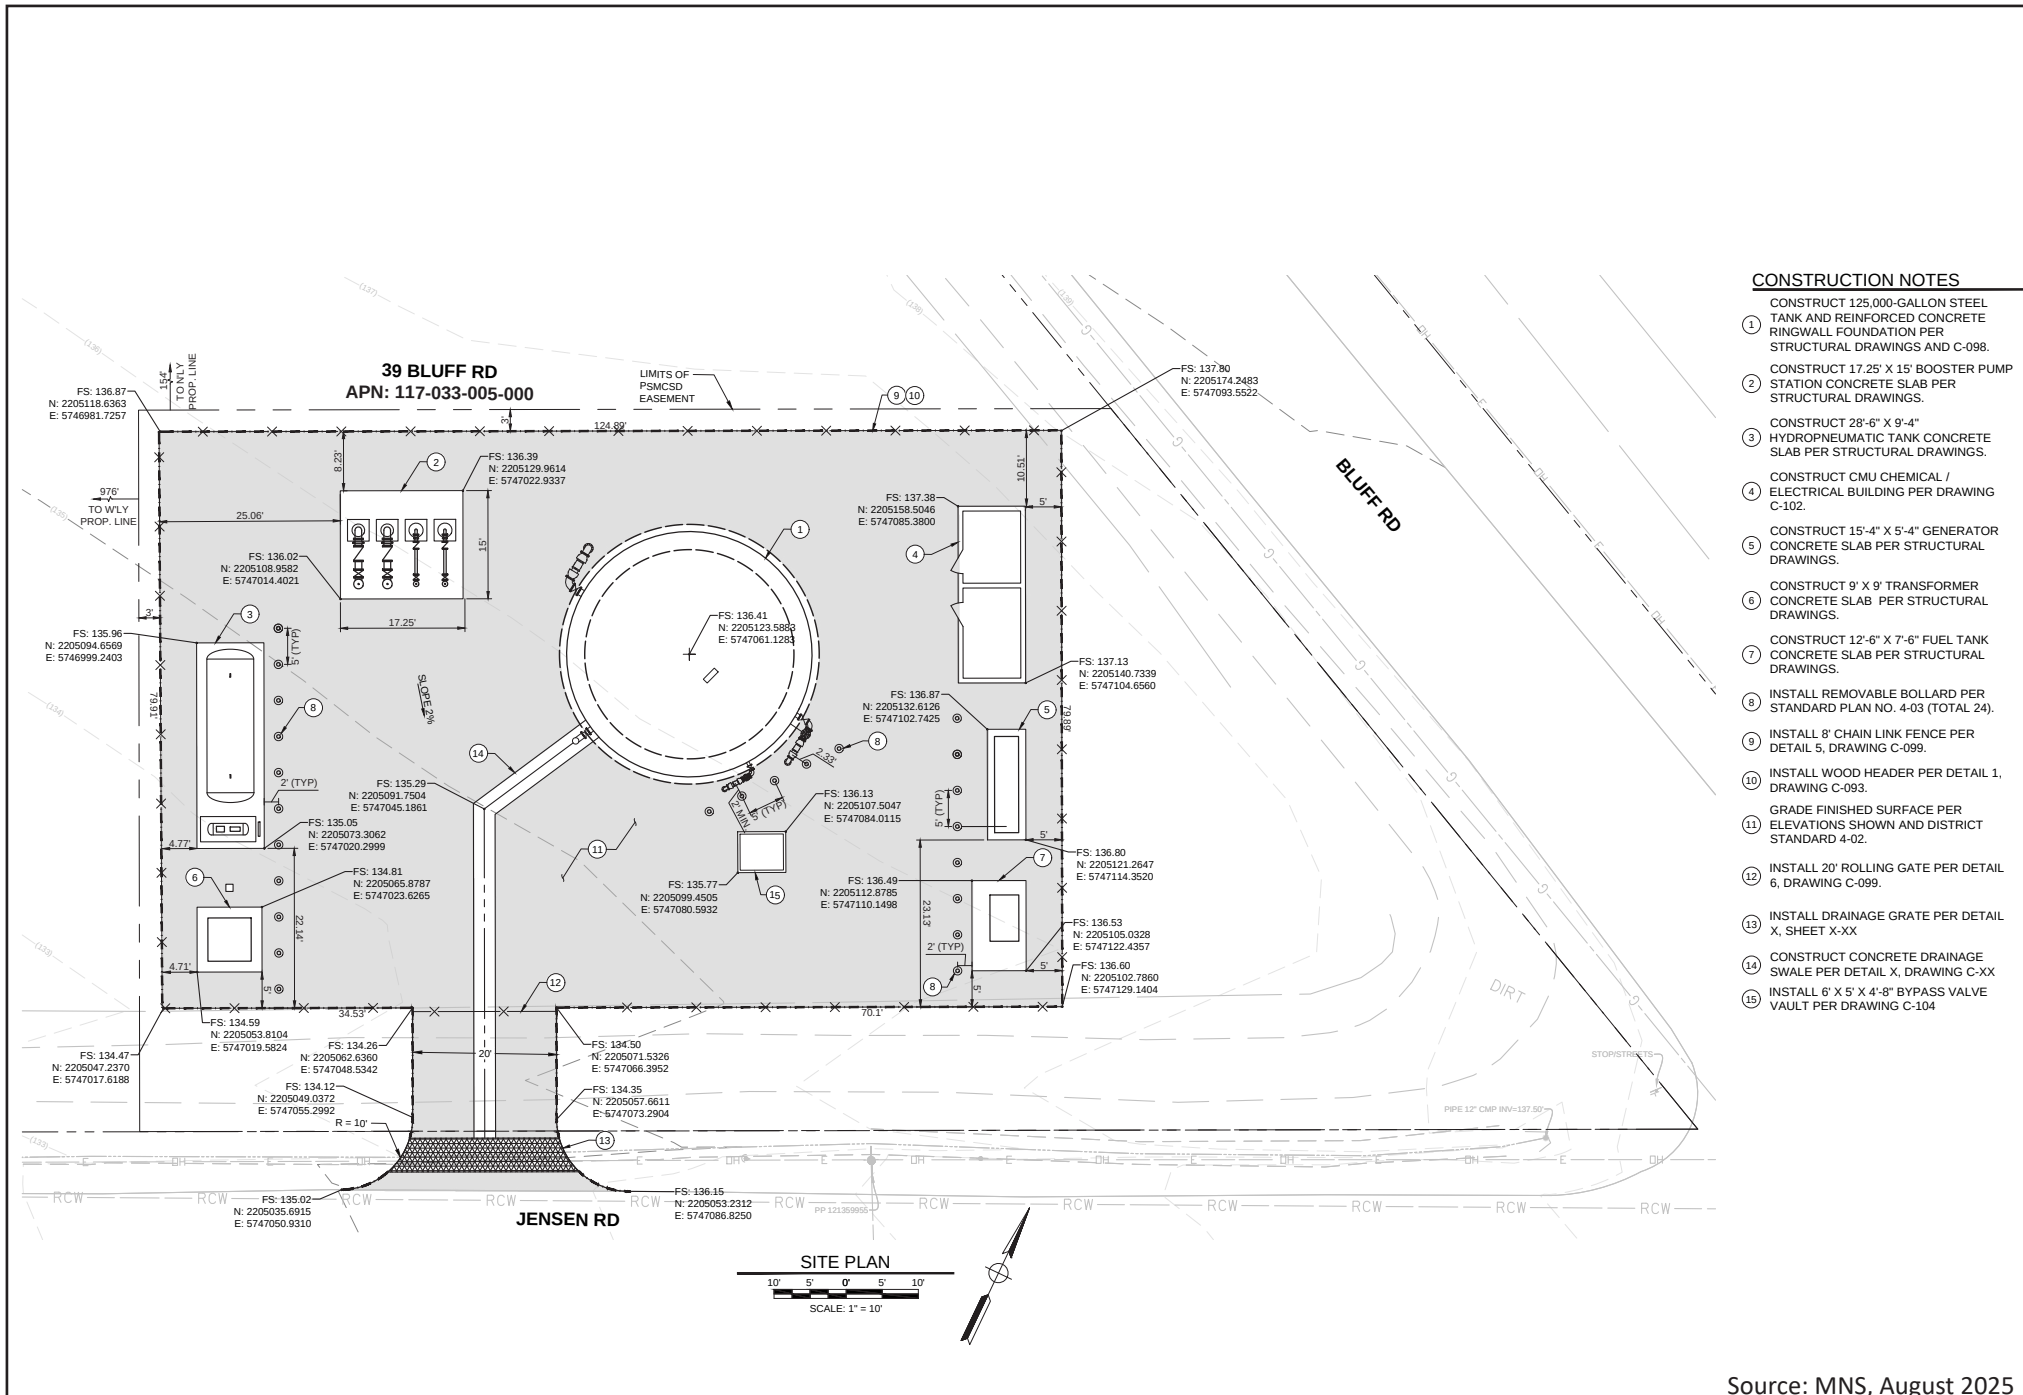

Source: MNS, August 2025

Title: Site Plan - Bluff/Jensen Site	Date 8/12/2025 Scale N/A Project 2023.47	Monterey San Jose Denise Duffy and Associates, Inc. Environmental Consultants Resource Planners 947 Cass Street, Suite 5 Monterey, CA 93940 (831) 373-4341	Figure 6d
--	--	--	---------------------------